


PLAN NOTES

1. REVIEW DIVISION 16 IN GENERAL CONSTRUCTION SPECIFICATIONS FOR ADDITIONAL SPECIFICATIONS AND ALLOWANCES REGARDING THE ELECTRICAL SCOPE OF WORK.
2. ELECTRICAL LAYOUT SHOWN SHALL BE REVIEWED PRIOR TO OR AT TIME OF ROUGH IN FOR ELECTRICAL FIXTURES (LAYOUT IS INTENDED TO QUANTIFY FIXTURES. LOCATIONS MUST BE APPROVED BY OWNER & ADJUSTED ACCORDINGLY). ALL OTHER ASPECTS OF THE ELECTRICAL LAYOUT (SWITCHES, OUTLETS, ETC.) SHALL BE DECIDED AT THE TIME OF WALK THROUGH, BASED ON THE ALLOWANCE OPENING IN THE BASE BID.
3. ELECTRICAL FIXTURE SCHEDULE AND SPECIFICATIONS SHALL OVERRIDE THESE PLANS SHOULD THERE BE ANY DISCREPANCIES BETWEEN THE PLANS AND SPECIFICATIONS.

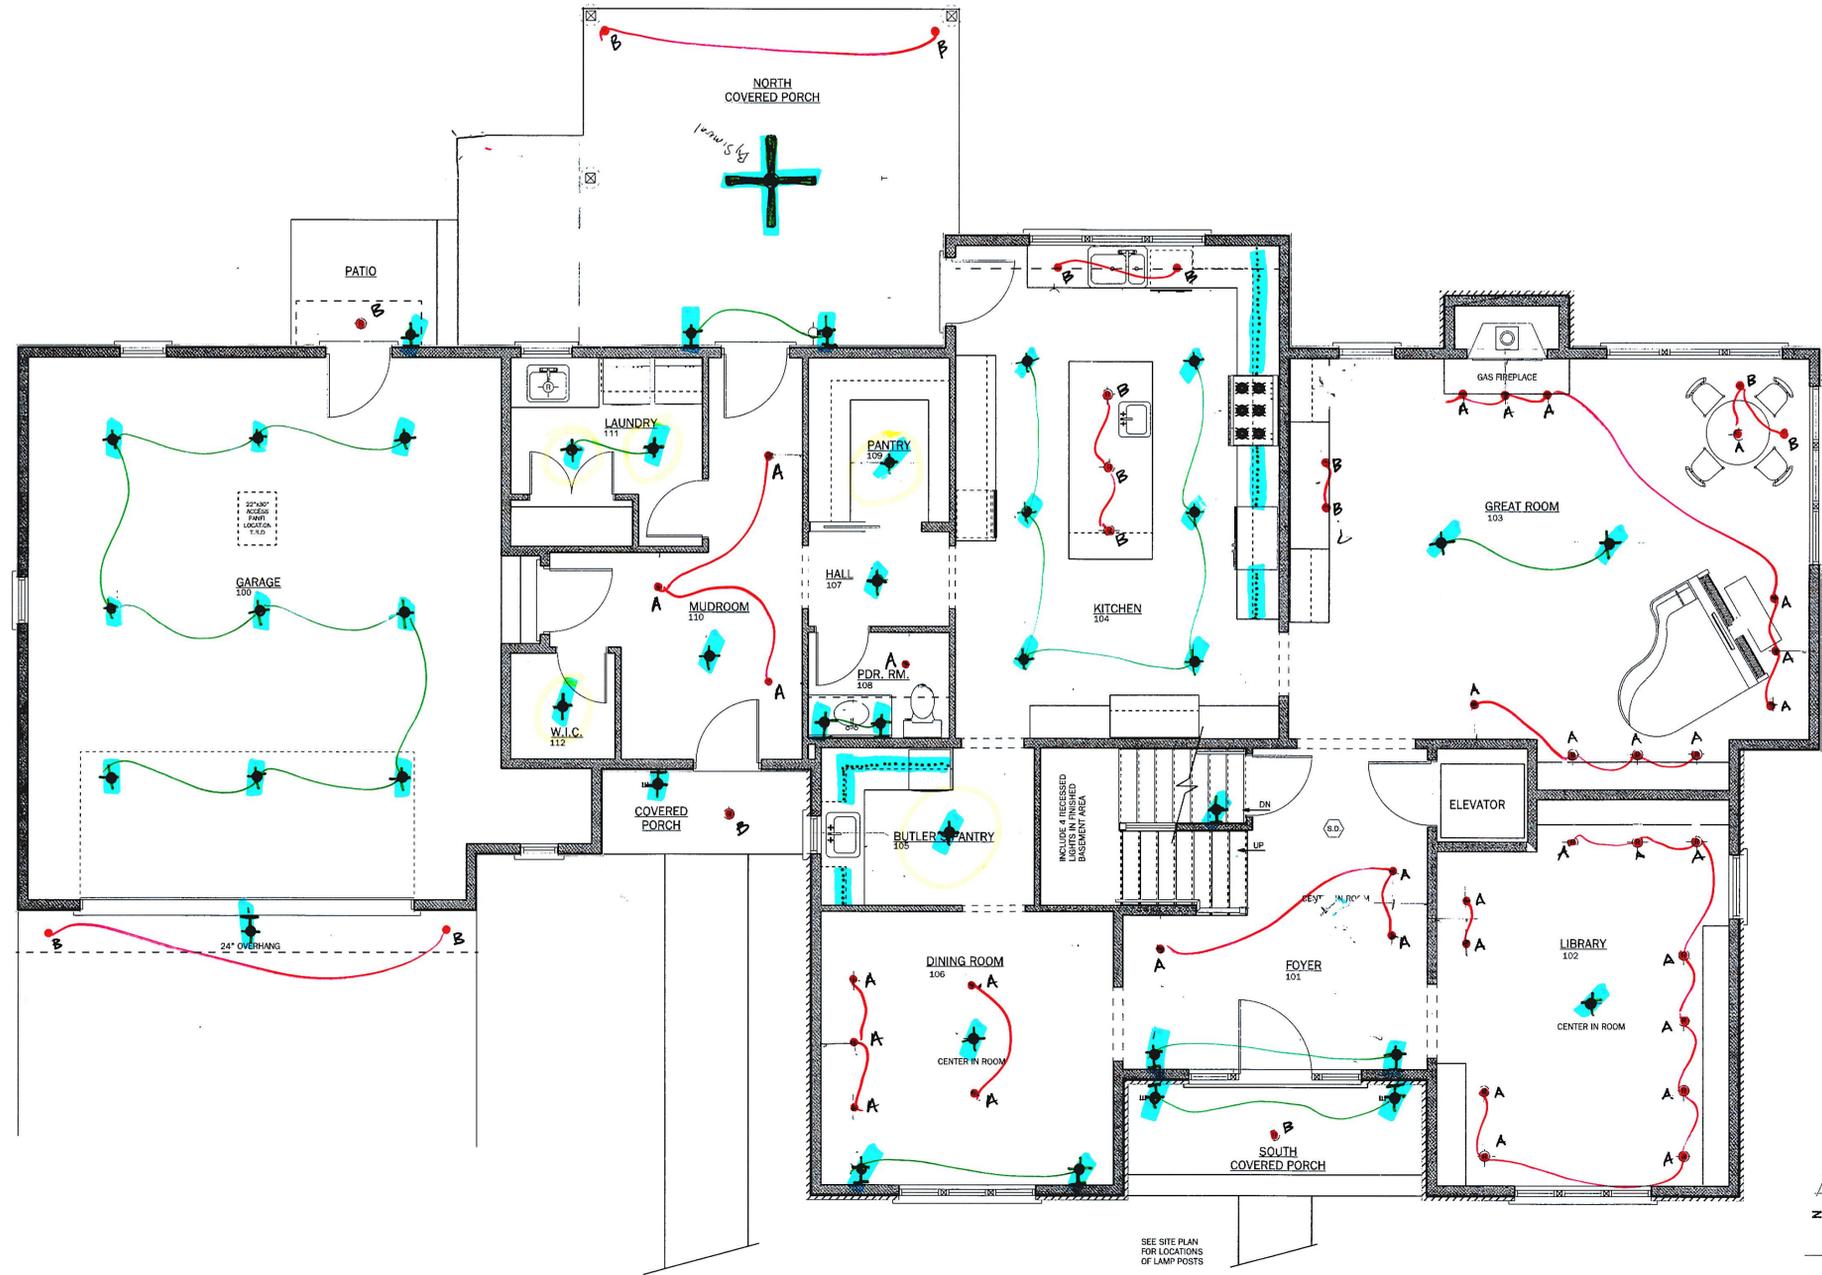

ELECTRICAL KEY

- A = Recessed Light Adjustable
- B = RECESSED LIGHT Downlight
- C = Recessed Light Dome
- ✦ = CEILING MOUNT LIGHT OR PENDANT OR HANGING FIXTURE
- ✦ = SCONCE
- ⊕ = EXHAUST FAN
- TV = TELEVISION
- = LED undercab
- ⊕ = EXHAUST FANLIGHT COMBO
- ⊕ = HEAT LAMP
- ✦ = CEILING FAN

A- 24
B- 14
C- 0

FIRST FLOOR FLOOR
SCALE: 1/4" = 1' - 0"

DO NOT USE ELECTRICAL PLANS FOR CONSTRUCTION OF BUILDING. PLAN IS ONLY FOR USE IN THE LAYOUT OF ELECTRICAL FIXTURES

OWNER: DR. LOSONSKY & MURPHY RESIDENCE
PROJECT: 319-17
DATE: 26 OCT 2020

SIMERAL
CONSTRUCTION COMPANY
PHILADELPHIA, PENNSYLVANIA 19104
PHONE: 717-460-6464
FAX: 717-460-6464
WWW.SIMERALCONSTRUCTION.COM

DRS. LOSONSKY & MURPHY RESIDENCE
LOT 28 FARM ON QUARRY ROAD
713 TADDINGTON LANE
LITITZ, PA 17543

REVISIONS:	DATE
TYPE OF ISSUE: BID SET	26 OCT 2020
DATE OF ISSUE:	26 OCT 2020
PRINT DATE:	@ DATE
SCALE AS NOTED	
DESIGN BY: B.H. SIMERAL	
DRAWN BY: J.R.H.	

SHEET NUMBER: **E-1**