

GROUND FLR ROOM LIST	
001	ELEVATOR
001	STAIR - A
002	ELECTRICAL ROOM
003	MECHANICAL ROOM
004	STAIR - B
005	UTILITY
006	CORRIDOR
007	STORAGE
008	TOILET
009	MAKER SPACE
010	WORKSHOP
011	CORRIDOR
012	BAND ROOM
013	SECTIONAL ROOM
014	BAND ROOM VESTIBULE
015	ELECT.
016	I.T.

**JMT ARCHITECTURE**  
 40 WIGHT AVENUE  
 HUNT VALLEY, MARYLAND 21030  
 410.372.4817  
 WWW.JMTARCHITECTURE.COM

**bkm**  
 Bardelle, Koehler, Murphy & Associates, Inc.  
 Mechanical / Electrical Engineers  
 6300 Blair Hill Lane, Suite 400 | Baltimore, Maryland 21209  
 P: 410.323.0600 | www.bkma.com


PROFESSIONAL CERTIFICATION: I HEREBY CERTIFY THAT THESE DOCUMENTS WERE PREPARED OR APPROVED BY ME AND THAT I AM A DULY LICENSED ENGINEER UNDER THE LAWS OF THE STATE OF MARYLAND. LICENSE NUM: 34744, EXP. DATE: 01/23/2021

PROJECT:  
**INNOVATIVE LEARNING CENTER**  
 NEW MIDDLE SCHOOL

500 CHESTNUT AVE  
 TOWSON, MD 21204

PREPARED FOR:  
 LOYOLA BLAKEFIELD


500 CHESTNUT AVE  
 TOWSON, MD 21204

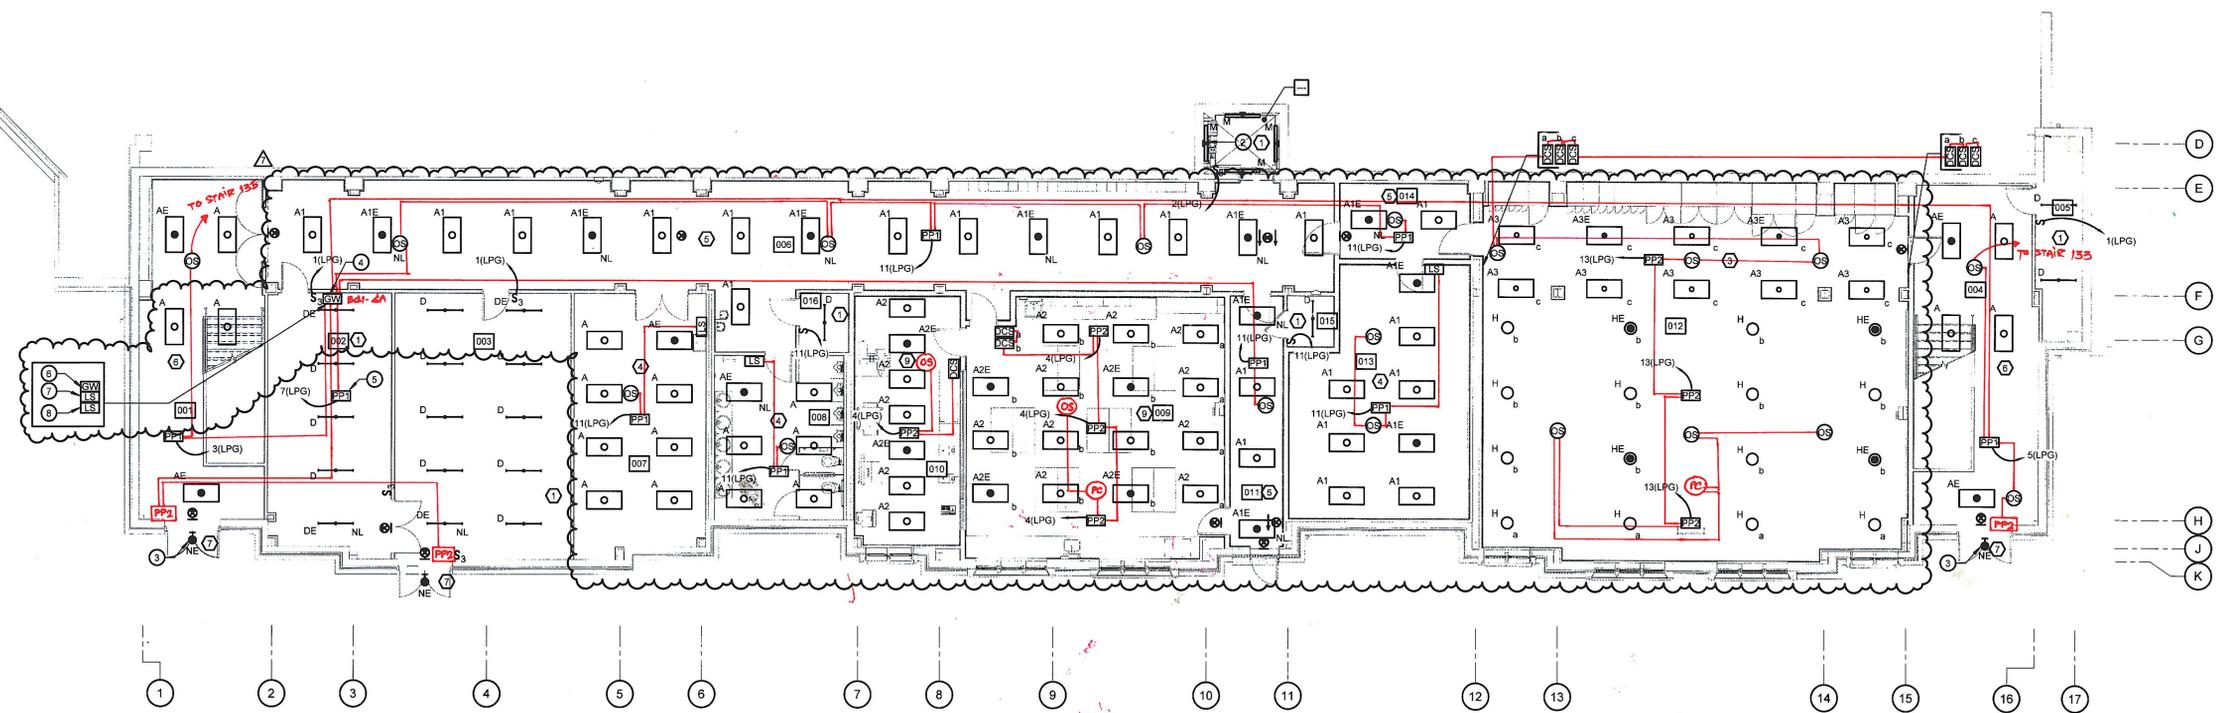

**1 GROUND FLOOR PLAN - LIGHTING**  
 SCALE: 1/8" = 1'-0"

- GENERAL NOTES:**
- REFER TO E001 FOR LEGEND, ABBREVIATIONS AND GENERAL NOTES.
  - REFER TO E002 FOR LIGHTING FIXTURE SCHEDULE, LIGHTING CONTROL LEGEND AND CONTROL SEQUENCE OF OPERATION.

 - DRAWING NOTES:**
- LIGHTING CONTROL SEQUENCE OF OPERATION. REFER TO DRAWING E002 FOR ADDITIONAL INFORMATION.
  - MOUNT LIGHT FIXTURE ON WALL OF ELEVATOR HOISTWAY. COORDINATE LOCATION OF LIGHT FIXTURES AND LIGHT SWITCH WITH ELEVATOR CONTRACTOR.
  - CONNECT TO NORMAL LIGHTING CIRCUIT SUPPLYING ASSOCIATED STAIRWELL.
  - PROVIDE LIGHTING CONTROL SYSTEM GATEWAY FOR TIME-BASED CONTROL OF EXTERIOR LIGHTS. COORDINATE LOCATION WITH OWNER.
  - PROVIDE DEDICATED POWER PACK FOR EXTERIOR SITE PATHWAY LIGHTING.
  - PROVIDE LIGHTING CONTROL SYSTEM GATEWAY FOR TIME-BASED CONTROL OF CORRIDOR LIGHTS. COORDINATE LOCATION WITH OWNER.
  - PROVIDE OVERRIDE SWITCHES FOR LIGHTING CONTROL SYSTEM CORRIDOR (ROOM 008) CONTROL ZONE. COORDINATE LOCATION WITH OWNER.
  - PROVIDE OVERRIDE SWITCHES FOR LIGHTING CONTROL SYSTEM ROOM 014 CONTROL ZONE. COORDINATE LOCATION WITH OWNER.



C:\Revit\Drawings\MEP\_Plan\_18044\01\_Loyola Blakefield\_Architectural.dwg 5/12/2020 8:01:44 AM