


- DRAWING NOTES**
- ① 3P. 200AMP DISCONNECT FUSE AT 150 AMPS. USING DUAL ELEMENT FUSES.
 - ② 3P. 200 AMP DISCONNECT FUSE AT 110 AMPS. USING DUAL ELEMENT FUSES.

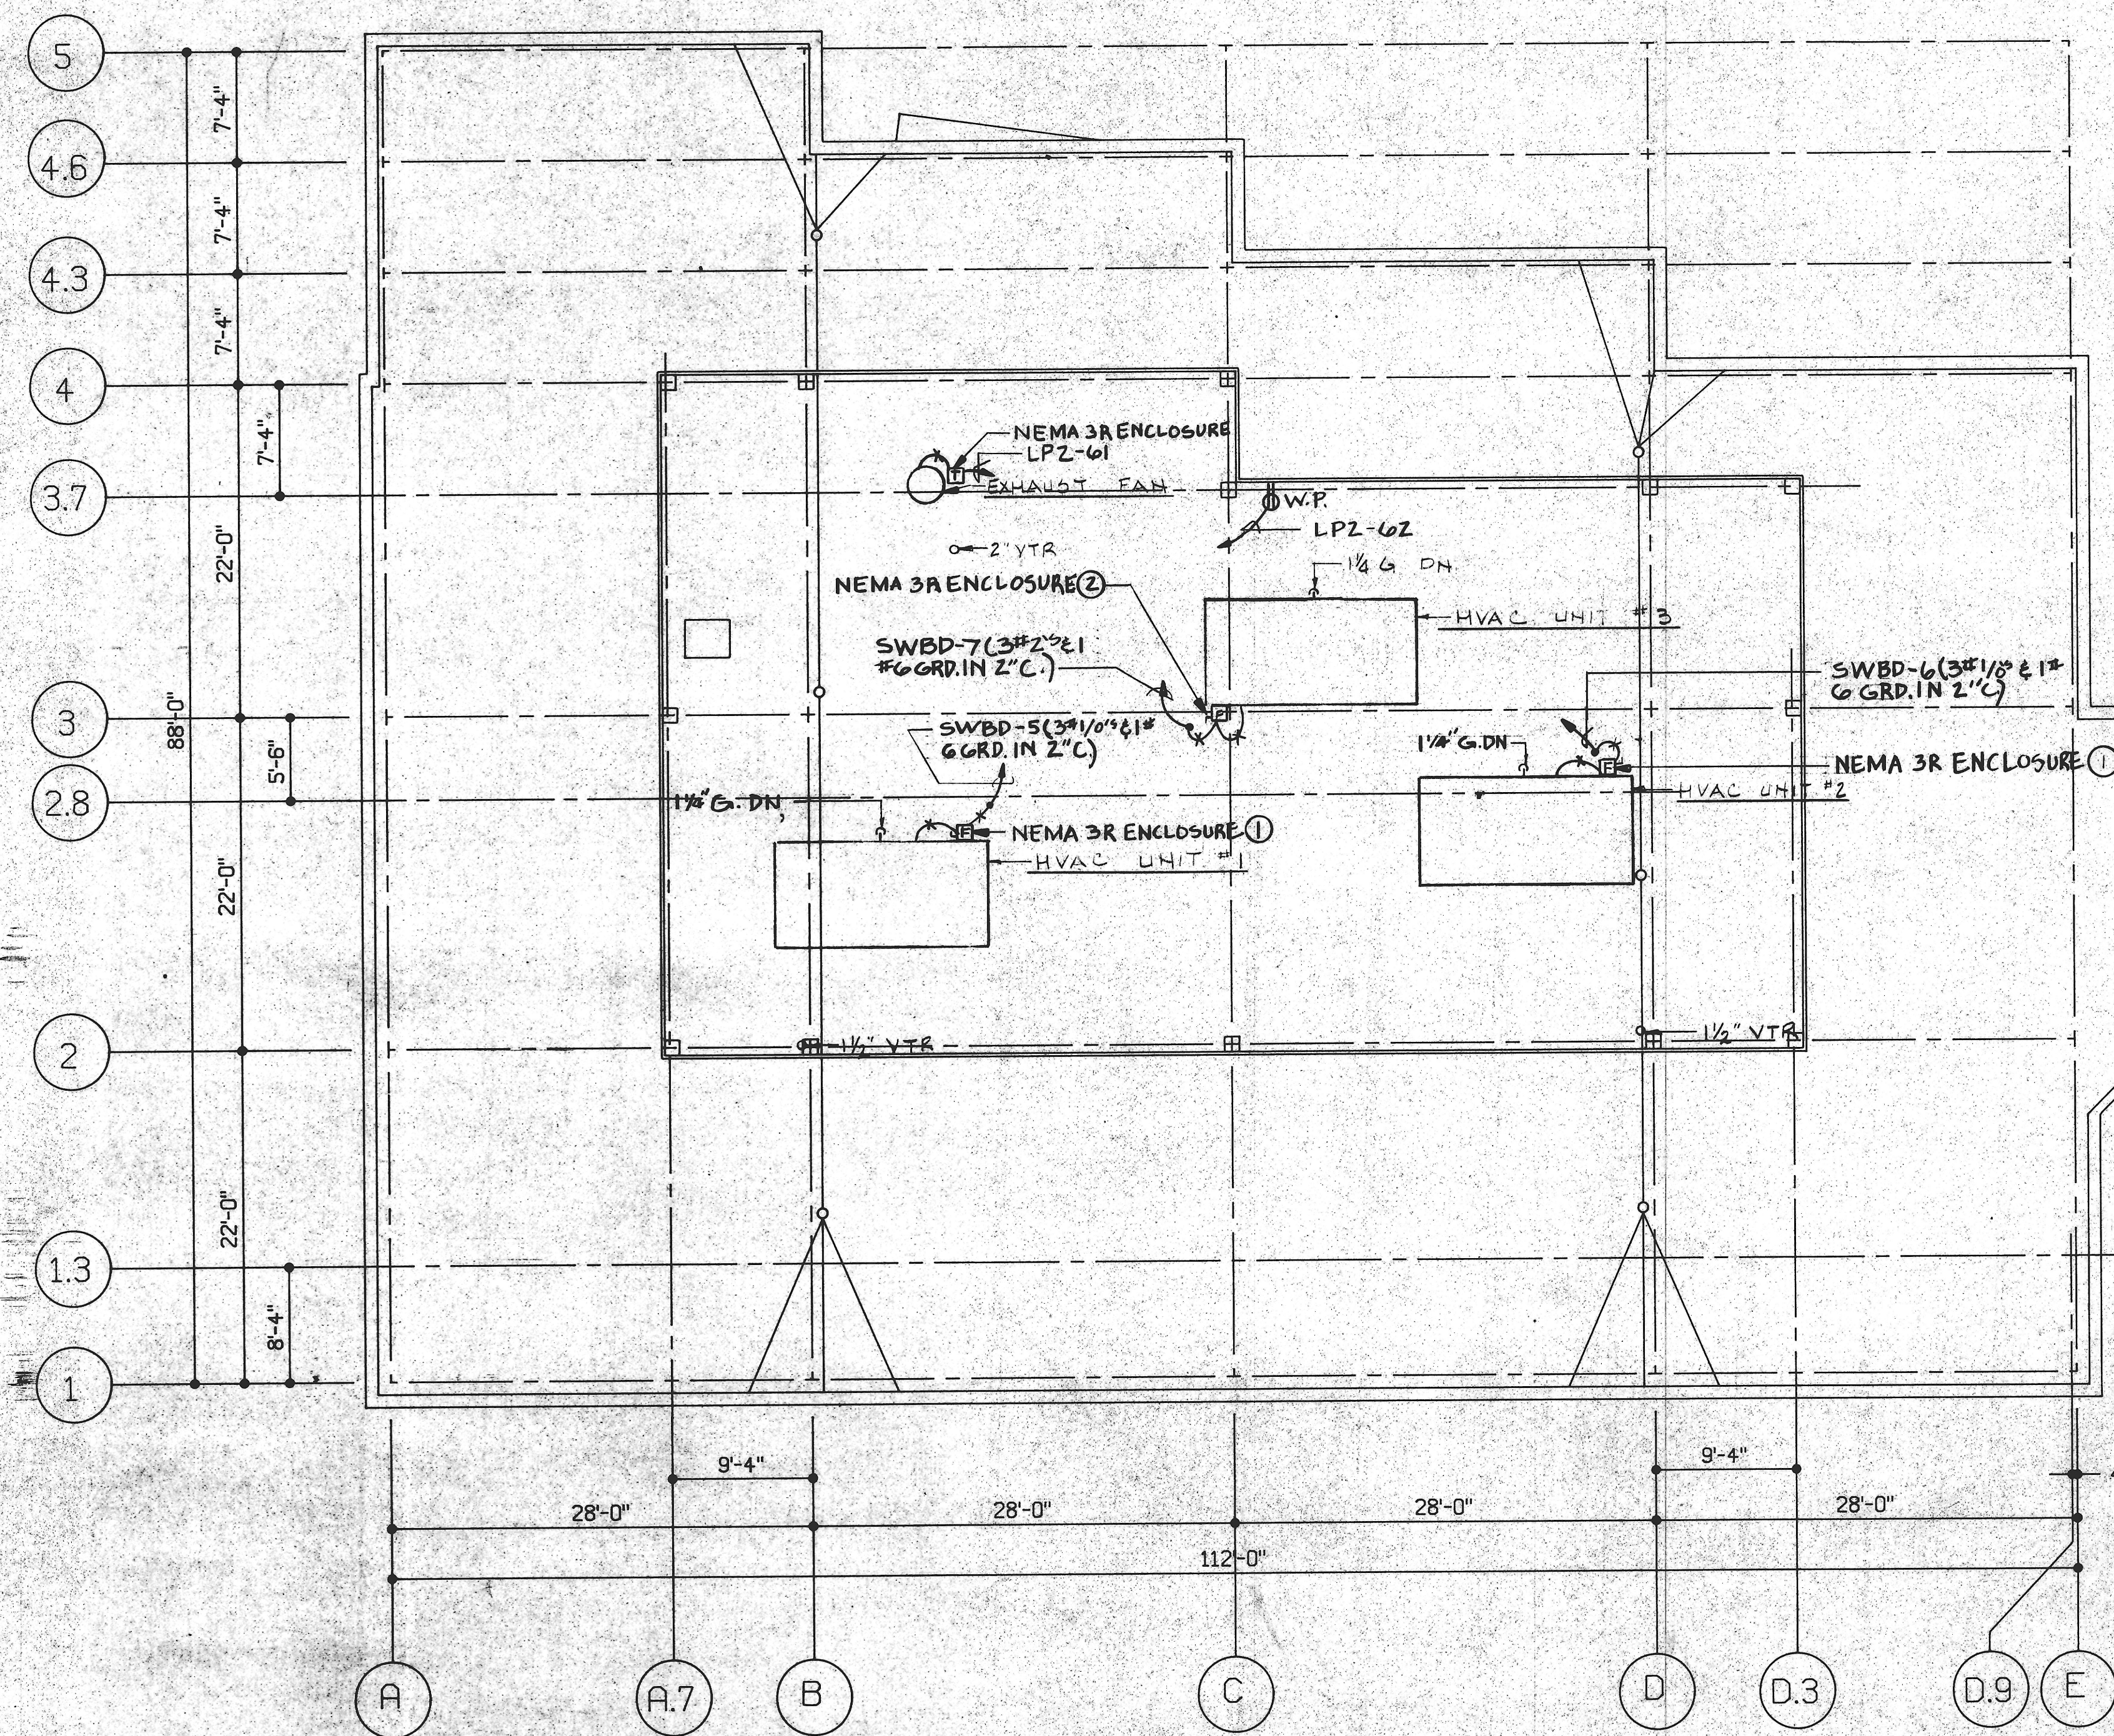

ROOF PLAN
SCALE: 1/8" = 1'-0"

KIBART, INC.
MECHANICAL ELECTRICAL ENGINEERS
698 FAIRMOUNT AVENUE
TOWSON, MARYLAND 21204

(301) 494-1111

LPJ, INC.
STRUCTURAL ENGINEERS
16 WEST 25th STREET
BALTIMORE, MARYLAND 21218

(301) 366-7800

Lapicki-Smith
ASSOCIATES, P.A.

THE PROFESSIONAL CENTER
211 WEST FAYETTE STREET
BALTIMORE, MARYLAND 21201
(301) 685-4900

project no. 86.30

1312 BELLONA AVENUE
LUTHERVILLE, MARYLAND

ZINK DEVELOPMENT COMPANY
1927 YORK ROAD
TIMONUM, MARYLAND 21083

drawing title
MECHANICAL/ELECTRICAL
ROOF PLAN

date 1.26.87 drawing no. ME-1

ME1	ME1
WA	WA