



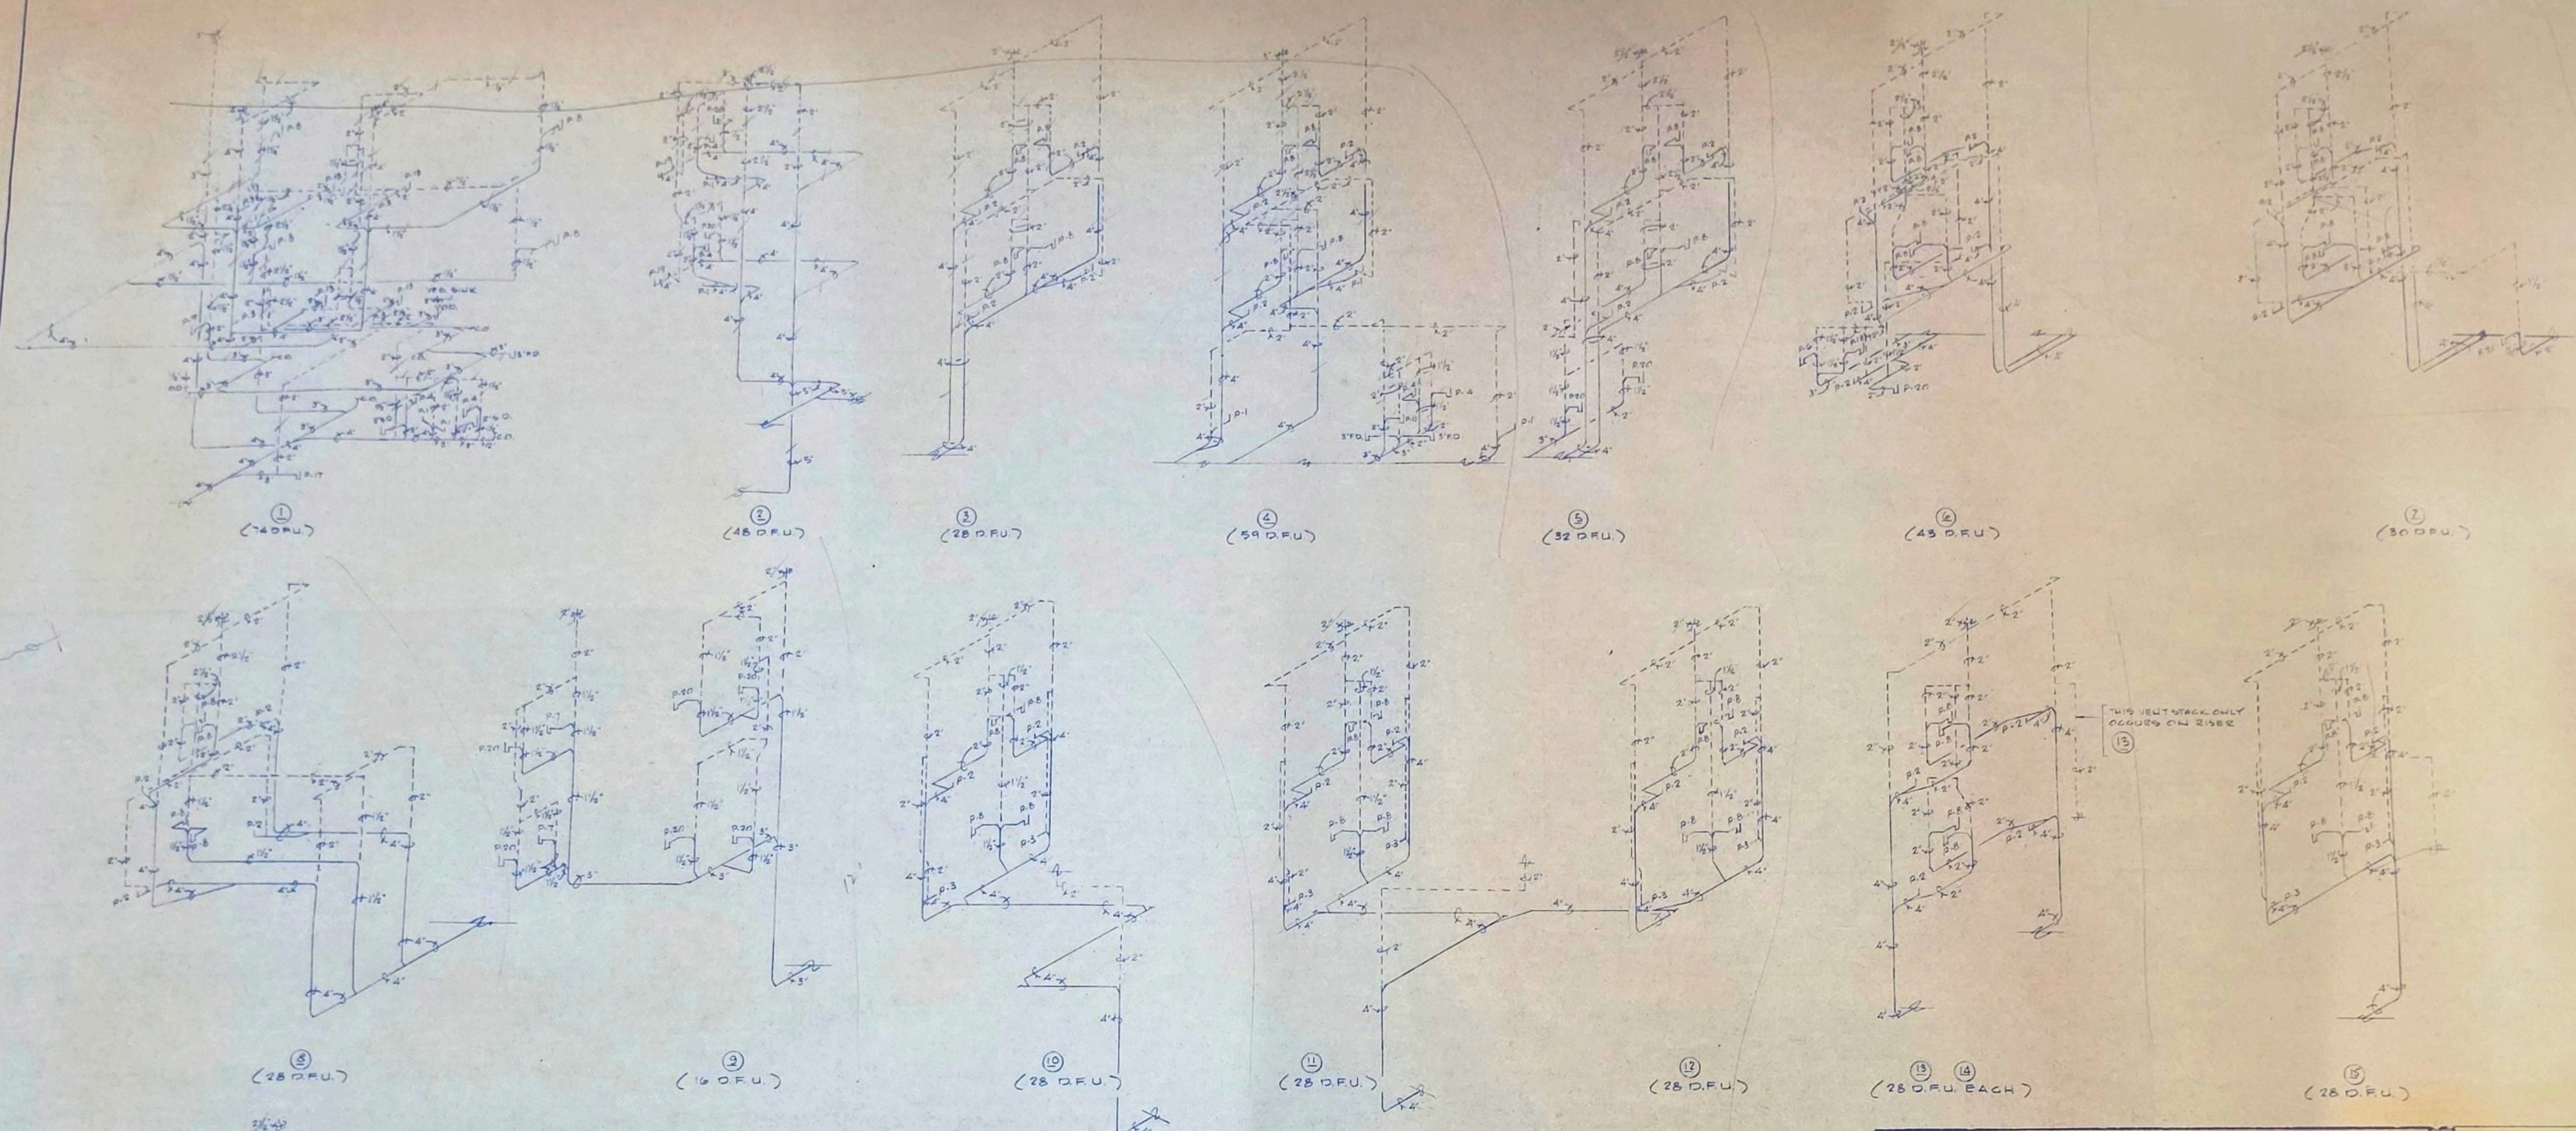

1. FOR FIXTURE SCHEDULE SEE DETAIL 2.
 2. FOR SYMBOLS SEE DETAIL 1.
 3. FOR ADDITIONAL GENERAL NOTES SEE DETAIL 3.

GENERAL NOTES

ROOF	0.4
SECOND FL.	0.4
FIRST FL.	11.0
GROUND FL.	0
BASEMENT	11
FLOOR HEIGHTS NOT TO SCALE	

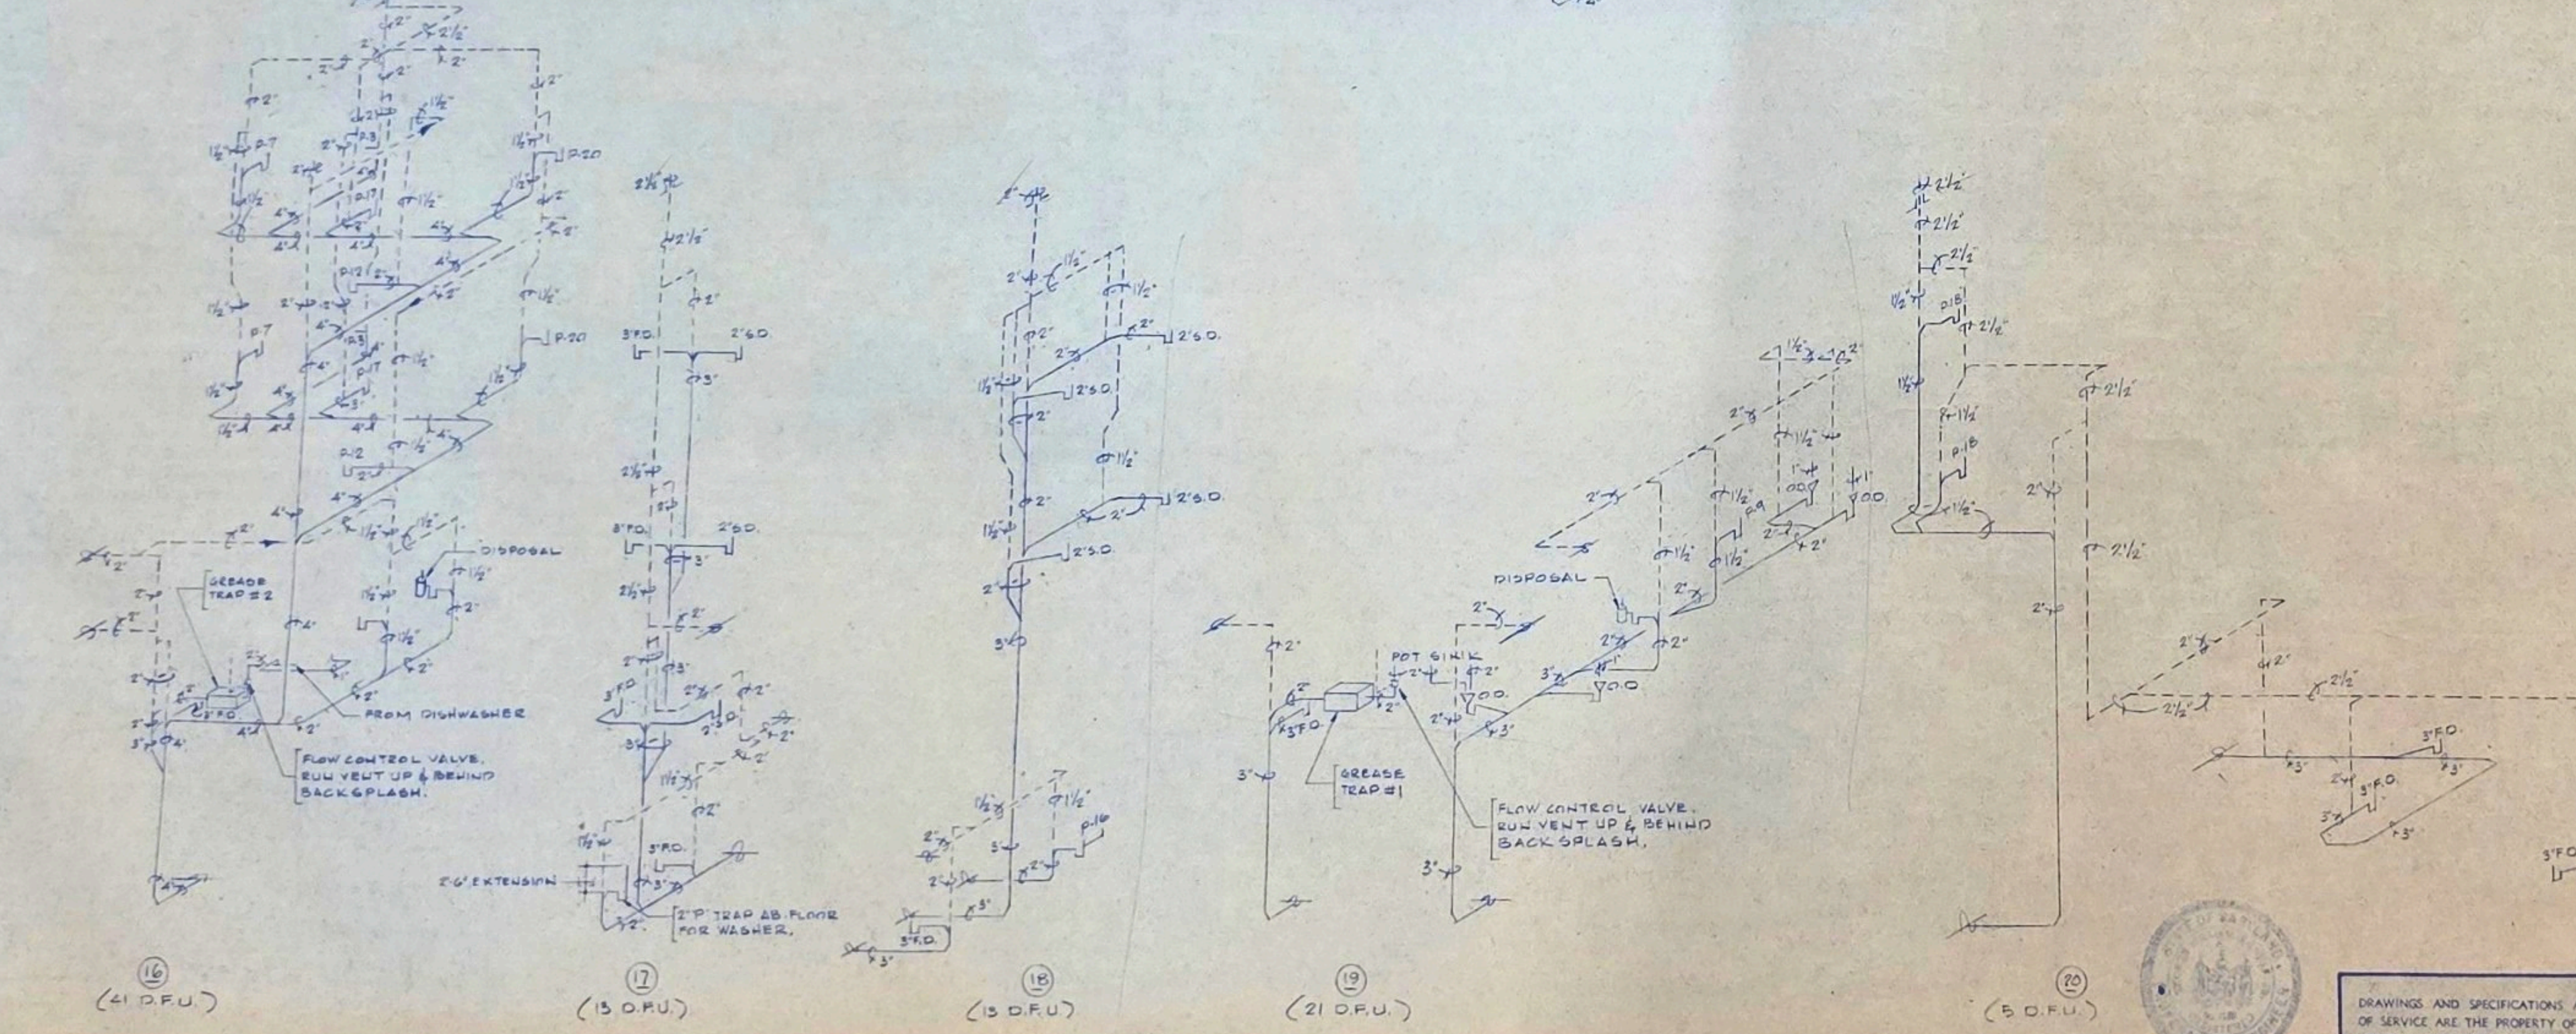

ROCKVILLE NURSING HOME INC
 301 ADCLARE ROAD ROCKVILLE, MARYLAND
eugene a delmar aia architect
 850 Sligo Ave. Silver Spring Md. 20910 Tel. 585-8300


job no. 72-1
 scale 1/8" = 1'-0"
 date 4-2-74
 drawn by S.M.
 checked S.M.

P4

1. FOR FIXTURE SCHEDULE SEE DETAIL 1
2. FOR SYMBOLS SEE DETAIL 2
3. FOR ADDITIONAL GENERAL NOTES SEE DETAIL 3
4. FOR FIRE EXTINGUISHERS AND CABINETS INFORMATION, SEE GENERAL NOTE 25 ON DETAIL 10
5. FOR TYPE OF ACCEPTABLE SOIL, WASTE AND VENT JOINTS IN KITCHEN, FOOD PREPARATION, FOOD STORAGE, FOOD SERVING AREAS, ETC., SEE SPECIFICATIONS.

GENERAL NOTES

CONNECT 1" S.P. LINE TO S.P. HEAD IN CHUTE. S.P. HEAD PROVIDED BY CHUTE MANUF.

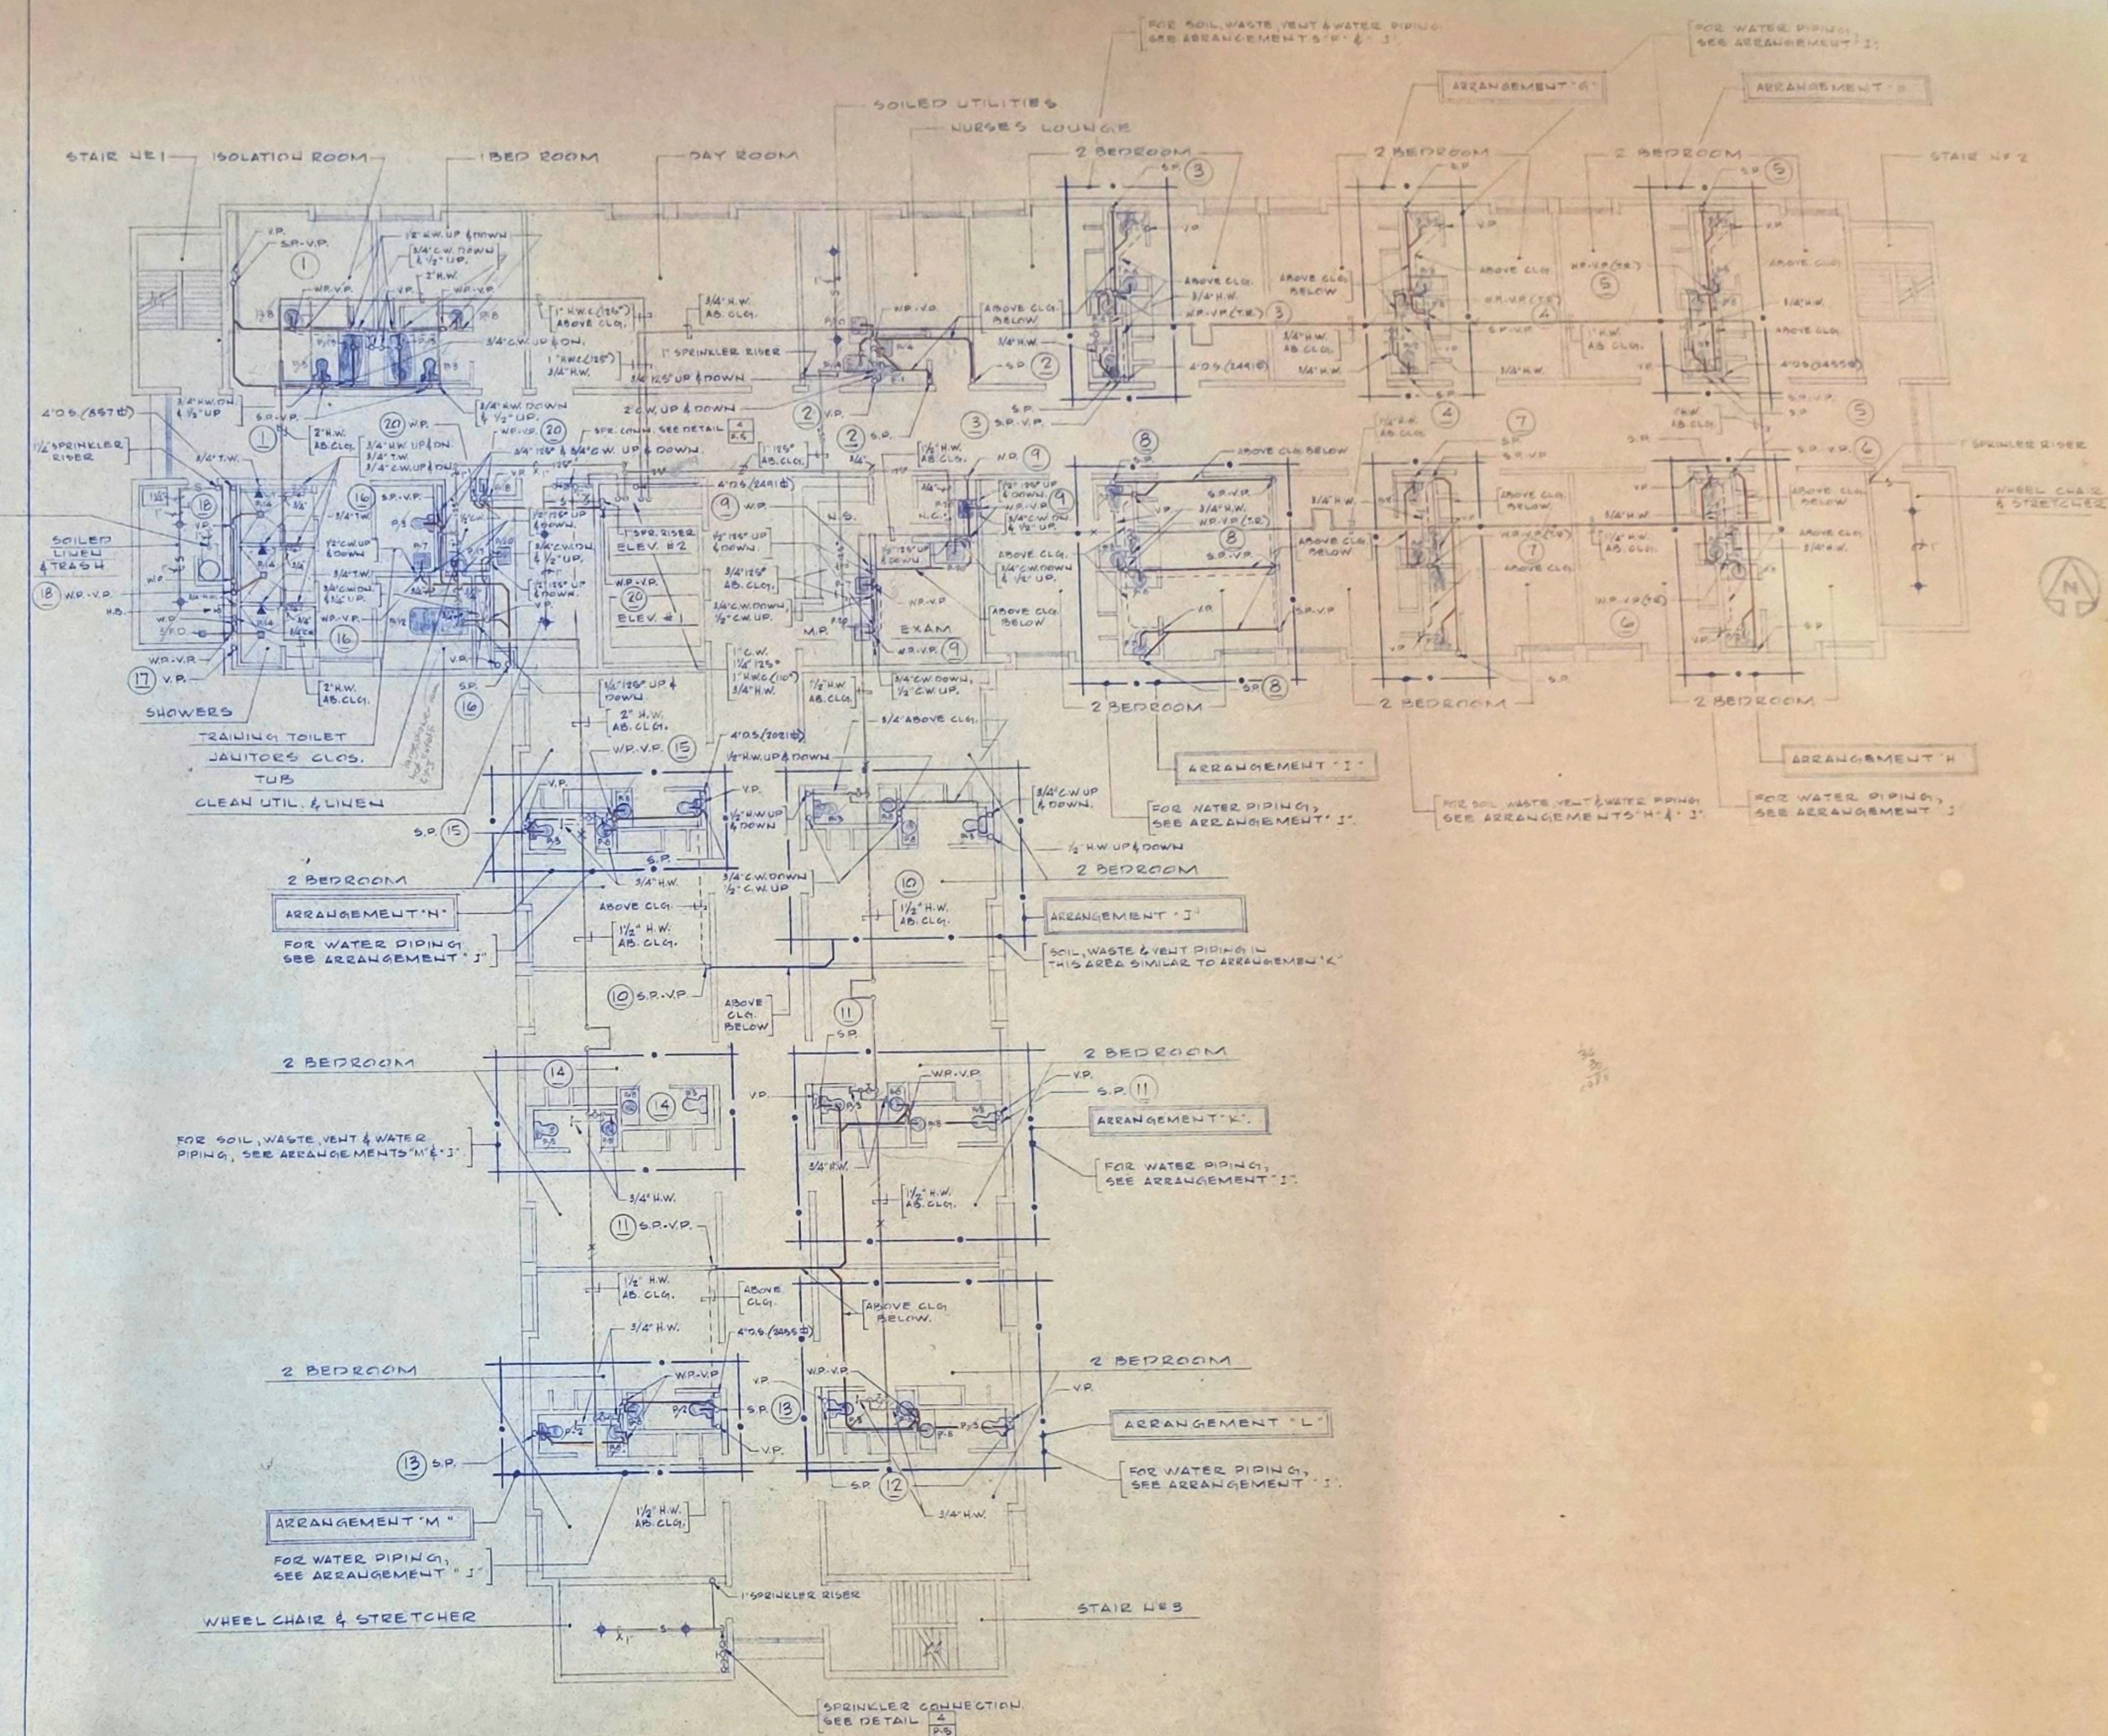

FIRST FLOOR PLAN

SCALE: 1/8" = 1'-0"

Second Floor
FIRST FLOOR PLAN - PLUMBING

DRAWINGS AND SPECIFICATIONS AS INSTRUMENTS OF SERVICE ARE THE PROPERTY OF THE ARCHITECT. WHETHER THE WORK FOR WHICH THEY ARE MADE BE EXECUTED OR NOT, AND ARE NOT TO BE USED OR COPIED ON OTHER WORK EXCEPT BY WRITTEN AGREEMENT WITH THE ARCHITECT.

CONTRACTOR TO VERIFY ALL DIMENSIONS AND CONDITIONS IN THE FIELD BEFORE PROCEEDING WITH THE WORK.

ROCKVILLE NURSING HOME INC
301 ADCLARE ROAD ROCKVILLE, MARYLAND
eugene a delmar aia architect
850 Sligo Ave. Silver Spring Md. 20910 Tel. 585-8300

job no. 77-1
scale 1/8" = 1'-0"
date 1-2-74
drawn by JWB
checked GAC

P 2

HUD-27

TWO 24" CONDUITS IN 3" CONCRETE ENVELOPE TO BE FURNISHED BY CONTRACTOR. TERMINATE AT TRANSFORMER PAD AS DIRECTED. CONCRETE TRANSFORMER PAD FURNISHED BY CONTRACTOR PER UTILITY CO. SPECIFICATIONS AND DIRECTIVES.

18" WY (6X3), 4" CONDUIT IN 3" CONCRETE ENVELOPE TO BE FURNISHED BY CONTRACTOR TO UTILITY CO. SPECIFICATIONS AND DIRECTIVES. MINIMUM DEPTH 30" TO TOP OF ENVELOPE. TERMINATE AT TRANSFORMER PAD AS DIRECTED BY THE UTILITY CO.

SYMBOLS

- SANITARY SEWER
- EXISTING SIGNS TO REMAIN
- EXISTING SIGNS TO BE REMOVED OR ABANDON
- WATER MAIN
- STORM SEWER
- GAS MAIN
- UNDERGROUND ELECTRIC SERVICE
- UNDERGROUND TELEPHONE SERVICE
- FIRE HYDRANT
- VALVE BOX
- LUMBER TYPE SEE SCHEDULE
- TOP ELEVATION
- POINT OF CONNECT NEW TO EXISTING PIPING
- BRANCH CIRCUIT NUMBER
- MANHOLE


1
OU-1
SYMBOLS

S I T E P L A N

S C A L E : 1" = 40' - 0"

1. ALL ON-SITE WATER AND SEWER LINE MATERIALS MUST BE INSPECTED BY THE LOCAL AUTHORITIES.
2. ALL CONSTRUCTION AND MATERIALS SHALL BE IN ACCORDANCE WITH LOCAL STANDARDS AND REGULATIONS.
3. FORM "AS BUILT" DRAWINGS TO BE FURNISHED BY THIS CONTRACTOR, SEE ARCHITECTURAL SPECIFICATIONS.
4. CONTRACTOR SHALL VERIFY LOCATION AND ELEVATIONS OF EXISTING FACILITIES BEFORE BUILDING ON-SITE WATER AND SEWERS.
5. ALL WATER PIPING 3" AND LARGER SHALL BE CAST IRON CLASS 22, CEMENT LINED, UNDER 3" TO BE TYPE "K" COPPER.
6. MANHOLES AND MANHOLE FRAME AND COVER SHALL CONFORM TO LOCAL STANDARDS.
7. ALL FIRE HYDRANTS, VALVE BOXES, ETC. SHALL BE LOCALLY APPROVED TYPE.
8. ALL WATER, SEWER, AND GAS INSTALLATION SHALL BE COORDINATED WITH STORM DRAINAGE, ELECTRIC, TELEPHONE AND HEATING PIPING, CONDUITS, ETC.
9. ALL CAST IRON SEWER PIPE SHALL BE EXTRA HEAVY (CS-185-L.E.).
10. WATER SERVICE TO HAVE MIN. 3'-6" COVER.
11. CONTRACTOR TO COORDINATE ALL INSTALLATIONS WITH STORM DRAINAGE DRAWINGS.
12. CONNECTED LOADS:
WATER 4.8 GPM, SANITARY 6.0 GPM, GAS 1.000 CU. FT./HR.
13. FOR MARKING LOCATIONS OF EXISTING WASHINGTON GAS LIGHT COMPANY FACILITIES, NOTIFY "MISS UTILITY" 555-0100, 48 HOURS PRIOR TO START OF ANY EXCAVATION OR CONSTRUCTION.
14. CONTRACTOR SHALL HAND DIG-TEST PITS AT ALL GAS CROSSINGS TO DETERMINE THE EXACT LOCATION AND DEPTH OF ALL GAS LINES WELL IN ADVANCE OF CONSTRUCTION.
15. PLUMBER SHALL NOTIFY THE LOCAL AUTHORITIES AT LEAST 48 HOURS PRIOR TO COMMENCING CONSTRUCTION OF ON-SITE SYSTEMS.
16. THE LOCATION OF EXISTING GAS FACILITIES SHOWN WERE OBTAINED FROM TRANSMISSION AND DISTRIBUTION DEPARTMENT OF WASHINGTON GAS LIGHT COMPANY.

GENERAL NOTES

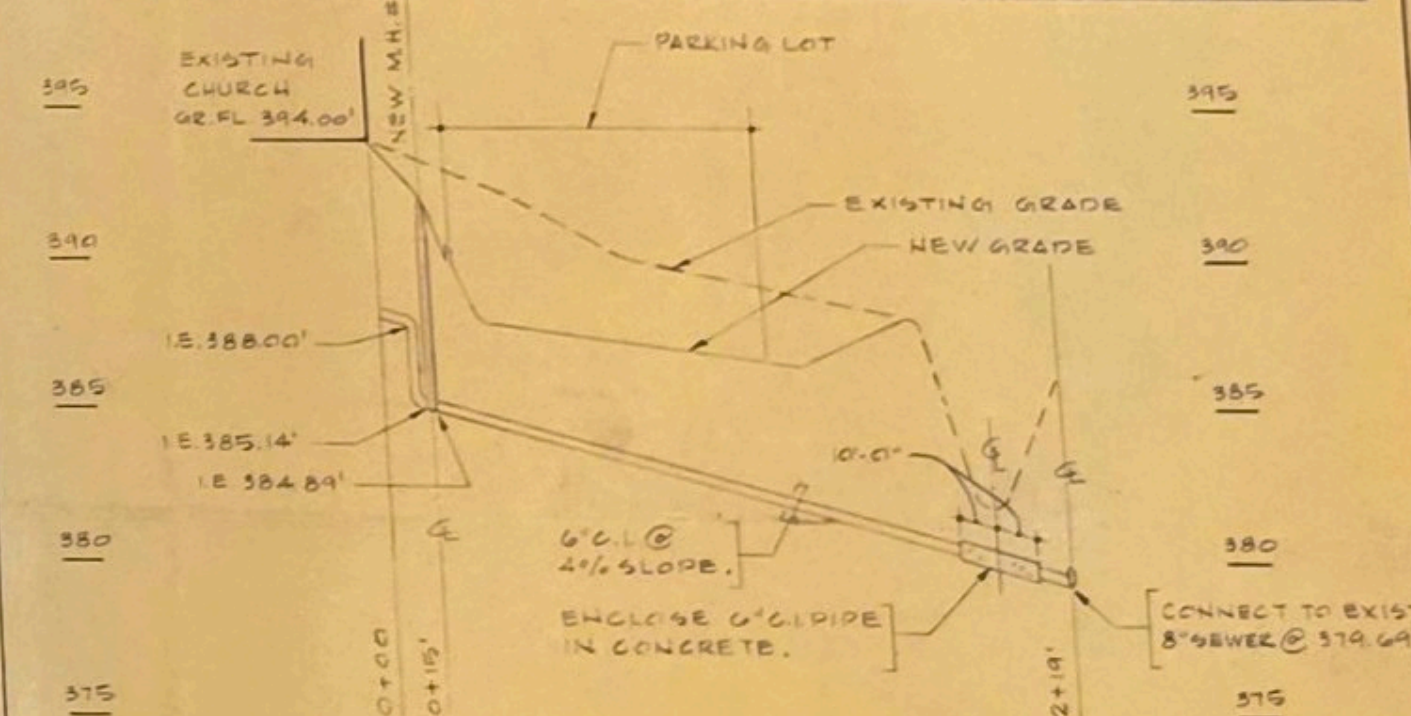

PROFILE NO. 1



PROFILE NO. 2

SEWER PROFILES

SCALE: HORIZ. 1"=40' VERT. 1"=4'

CUSTOM ELECTRIC

HUD-25

SITE PLAN & PROFILES - PLUMBING

DRAWINGS AND SPECIFICATIONS AS INSTRUMENTS OF SERVICE ARE THE PROPERTY OF THE ARCHITECT. WHETHER THE WORK FOR WHICH THEY ARE MADE BE EXECUTED OR NOT, AND ARE NOT TO BE USED OR COPIED ON OTHER WORK EXCEPT BY WRITTEN AGREEMENT WITH THE ARCHITECT.


CONTRACTOR TO VERIFY ALL DIMENSIONS AND CONDITIONS IN THE FIELD BEFORE PROCEEDING WITH THE WORK.

ROCKVILLE NURSING HOME INC
301 ADCLARE ROAD ROCKVILLE, MARYLAND
eugene a delmar aia architect
850 Sligo Ave. Silver Spring Md. 20910 Tel. 585-8300

job no. 72-1
scale 1/8"=1'-0"
date 4-2-74
drawn by JWB
checked G.E.

OU1

 
GENERAL NOTES



SECOND FLOOR PLAN - PLUMBING

job no	72-1
scale	42 542W
date	4-2-74
drawn by	JWE
checked	JWE

P 3

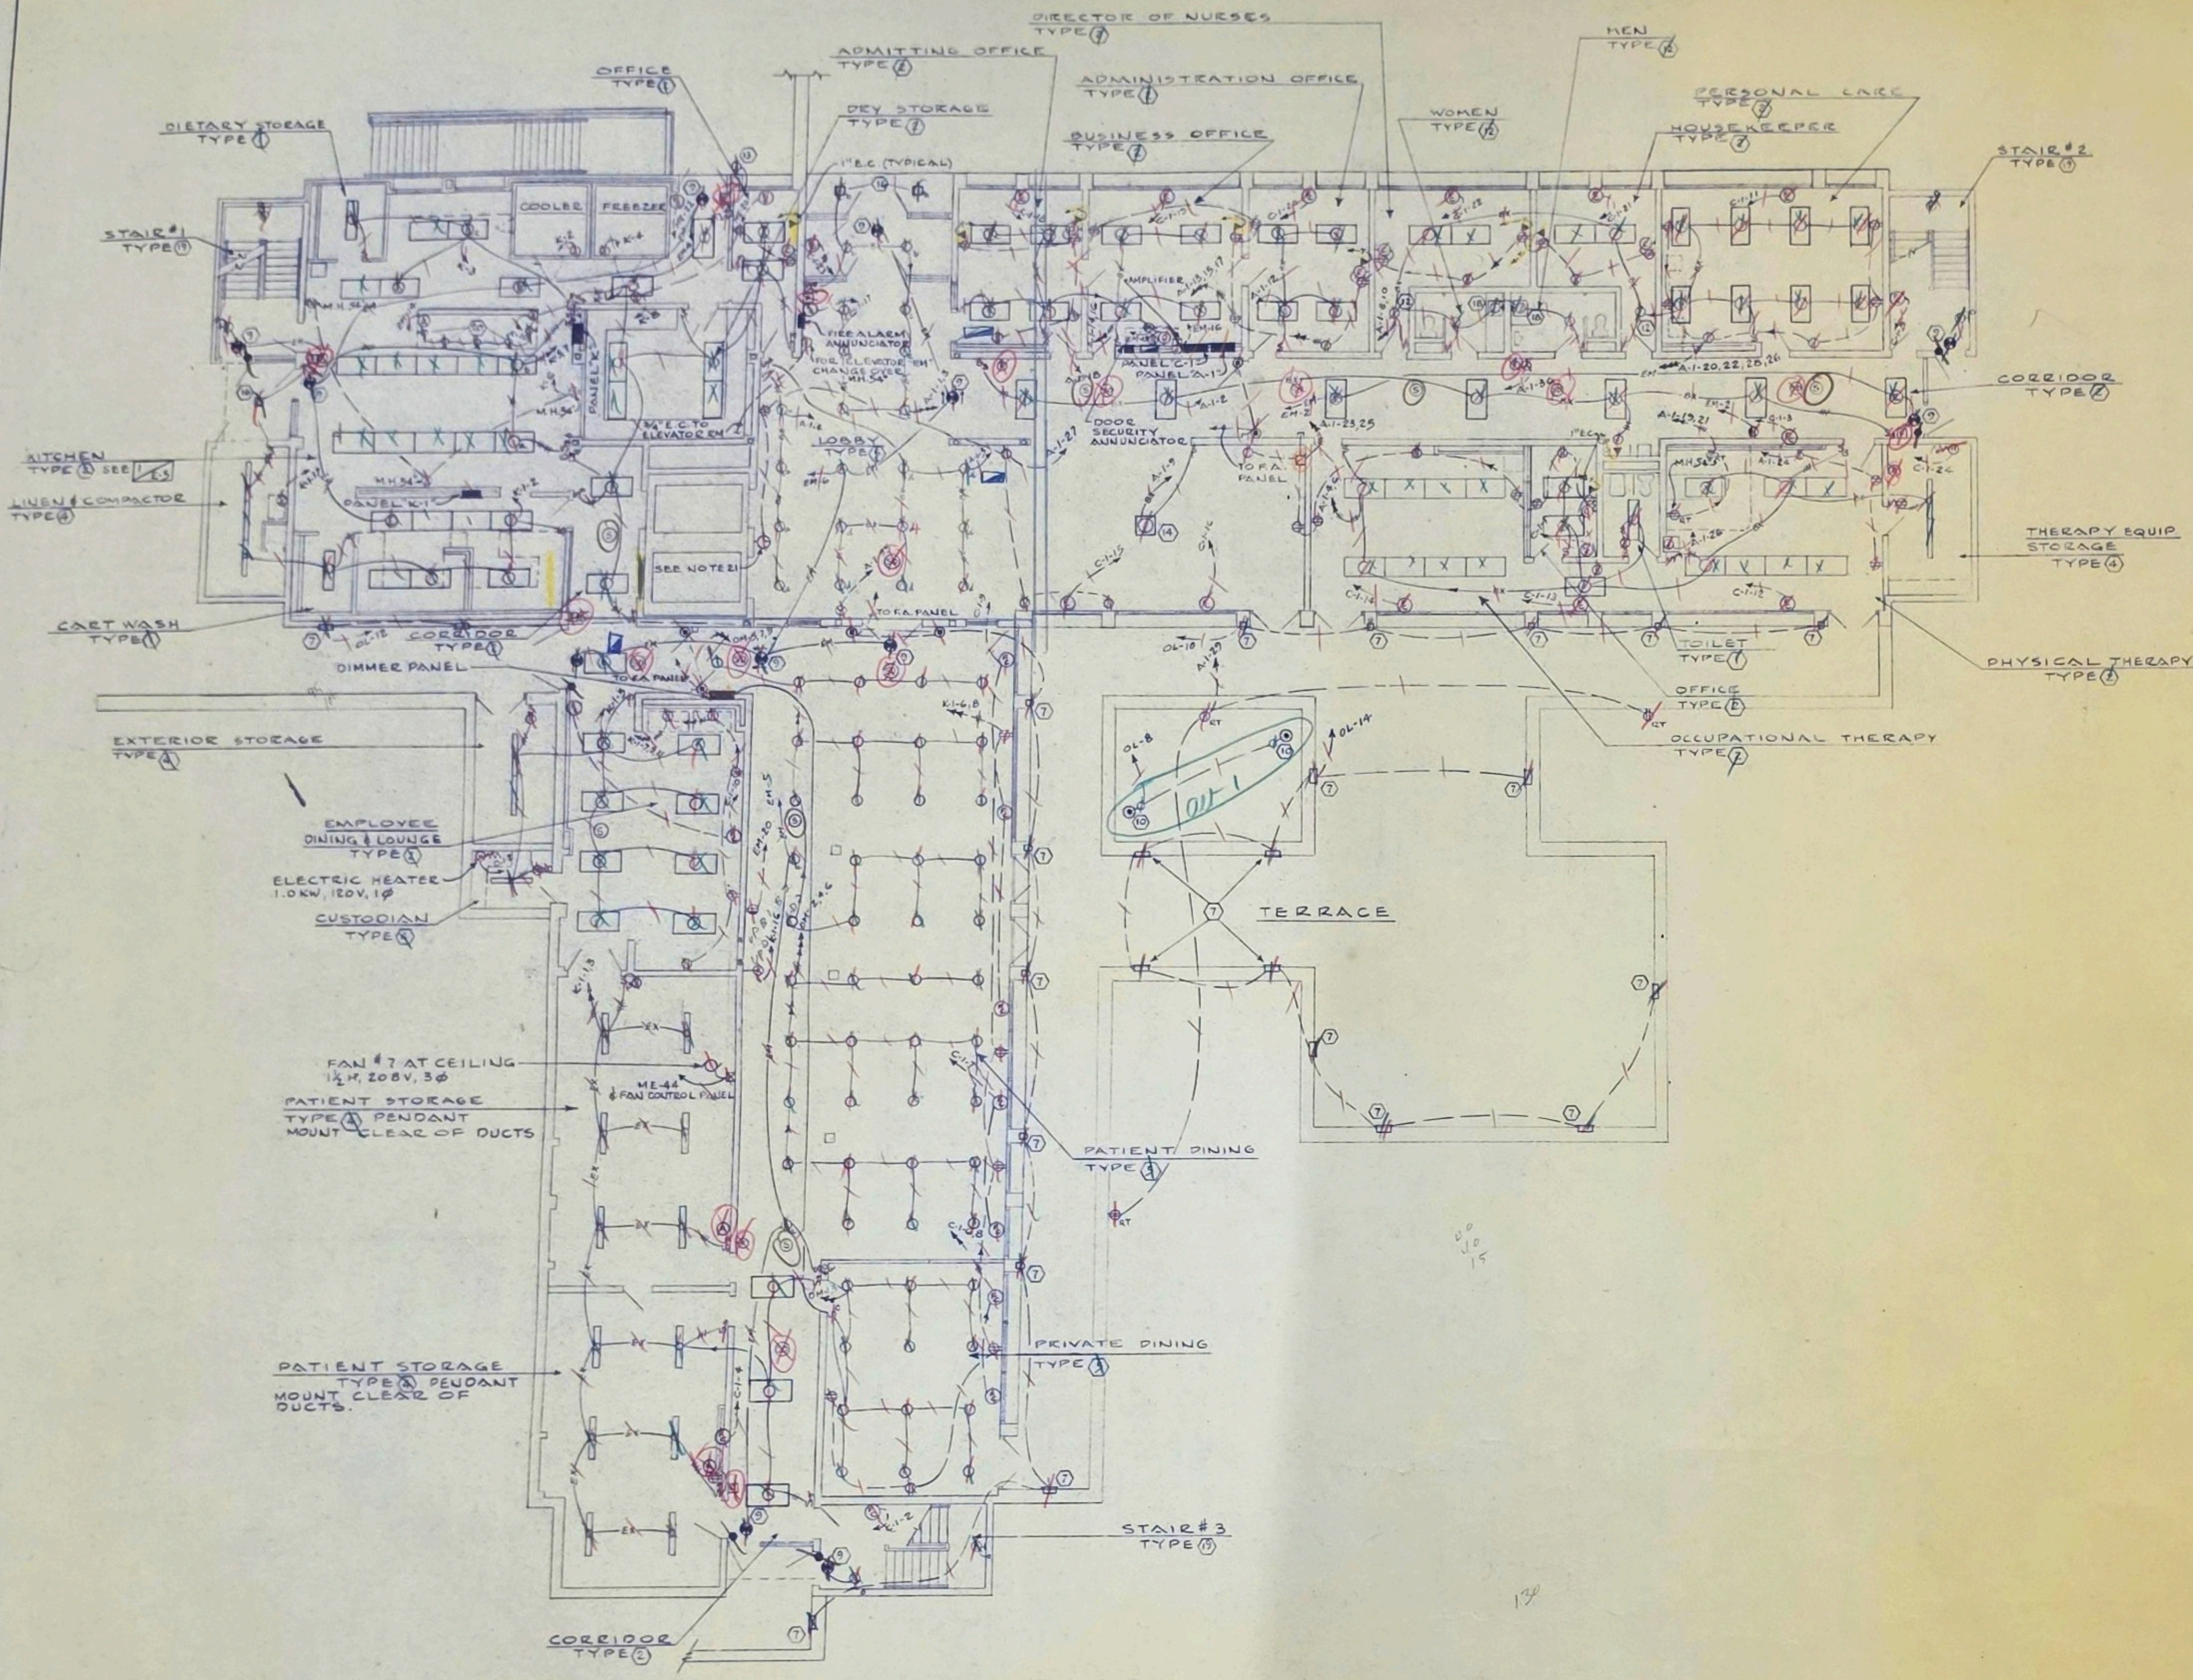

PANEL A
TYPE NQ05, 208/120 VOLTS, 3 PHASE, 4 WIRE, 225 A MAINS, LUGS ONLY

CIRCUIT NUMBER	BRANCH	CIRCUIT POLE	FRAME	BREAKERS TRIP	CONDUCTOR SIZE	CONDUIT SIZE	SERVING
13, 15		1	300A	Q	20A	#12	RECEPTACLES
14, 16						#12	LIGHTS
17, 18						#12	RECEPTACLES
19, 21, 29						#12	RECEPTACLES
20, 22						#12	RECEPTACLES
23, 24						#12	RECEPTACLES
25, 27						#12	RECEPTACLES
26, 28						#12	RECEPTACLES
30 THRU 34						#12	SPACES
35, 36						#10	CLEANING RECEPTACLES

* PROVIDE AND INSTALL SQUARE D QWIK-GARD 20A, 1P, 120V CIRCUIT BREAKER WITH GROUND FAULT PROTECTION.

PANEL C-1
TYPE NA1B, 208/120 VOLTS, 3 PHASE, 4 WIRE, 225 A MAINS, LUGS ONLY

CIRCUIT NUMBER	BRANCH	CIRCUIT POLE	FRAME	BREAKERS TRIP	CONDUCTOR SIZE	CONDUIT SIZE	SERVING
1 THRU 6		1	100A	FA	20A	#10	FAN COIL UNITS
11 THRU 10						#10	FAN COIL UNITS
11 THRU 10						#10	FAN COIL UNITS
15 THRU 20						#12	FAN COIL UNITS
21 THRU 24						#12	FAN COIL UNITS & ELECTRIC HEATERS
25, 27							SPACES
26, 28							SPACES

PANEL C-2
TYPE NQ05, 208/120 VOLTS, 3 PHASE, 4 WIRE, 225 A MAINS, LUGS ONLY WITH 3P, 200A, 3P, 3Ø 90° BREAKER CONTACTOR COMPLETE WITH FUSED COIL AND 100% DEF. RELAY

CIRCUIT NUMBER	BRANCH	CIRCUIT POLE	FRAME	BREAKERS TRIP	CONDUCTOR SIZE	CONDUIT SIZE	SERVING
1, 3, 5		1	500A	Q	20A	#10	LIGHTS
2, 4, 6						#10	POLE FLOOD LIGHTS
7, 9, 11						#10	LIGHTS
8, 10, 12, 14						#10	PATIO LIGHTS
13						#10	SIGN
15 THRU 22						#10	SPACES
23 THRU 26						#10	POLE LIGHTS
27, 29, 31						#10	POLE LIGHTS
28, 30, 32						#10	SPACES

PANEL E-M
TYPE NQ05, 208/120 VOLTS, 3 PHASE, 4 WIRE, 225 A MAINS, LUGS ONLY

CIRCUIT NUMBER	BRANCH	CIRCUIT POLE	FRAME	BREAKERS TRIP	CONDUCTOR SIZE	CONDUIT SIZE	SERVING
1, 3, 5		1	500A	Q	20A	#10	LIGHTS
2, 4, 6						#10	LIGHTS & RECEPTACLES
7, 9						#10	POWER PACKS
8, 10, 12						#10	TRIPPOLE CIRCUIT BREAKERS AND ANTI-LOCK
13, 16						#10	CO-ORDINATE LIGHTS
14, 18, 19						#10	ELEVATOR LIGHTS
11, 15						#10	SWEEP GEN. HEATER
17						#10	RECEPTACLES
20 THRU 24						#10	RECEPTACLES
25						#12	FIRE ALARM
26, 27, 29						#10	RECEPTACLES
31, 33, 35						#10	SPACES
32, 34, 36						#10	SPACES

PANEL E-M-1
TYPE NA1B, 208/120 VOLTS, 3 PHASE, 4 WIRE, 400A MAINS, LUGS ONLY

CIRCUIT NUMBER	BRANCH	CIRCUIT POLE	FRAME	BREAKERS TRIP	CONDUCTOR SIZE	CONDUIT SIZE	SERVING
1, 3, 5		1	100A	FA	20A	#10	SPACES
2, 4, 6						#10	SPACES
7, 8						#12	AIR COMPRESSORS
9, 10						#12	BOILERS
11						#12	SUMP PUMP
12						#12	SUMP PUMP
13						#6	WATER CIRC. PUMP
14						#6	STAND-BY PUMP
15, 16						#30	ELEVATOR

* PROVIDE SHUNT TRIPS ACTIVATED BY BOILER EM DISCONNECT



COMM. NO. 72-1331
7910 WOODMONT AVE.

DRAWINGS AND SPECIFICATIONS AS INSTRUMENTS OF SERVICE ARE THE PROPERTY OF THE ARCHITECT. WHATEVER THE WORK FOR WHICH THEY ARE MADE BE EXECUTED OR NOT, AND ARE NOT TO BE USED OR COPIED ON OTHER WORK EXCEPT BY WRITTEN AGREEMENT WITH THE ARCHITECT.

CONTRACTOR TO VERIFY ALL DIMENSIONS AND CONDITIONS IN THE FIELD BEFORE PROCEEDING WITH THE WORK.


ROCKVILLE NURSING HOME INC
301 ADCLARE ROAD ROCKVILLE, MARYLAND

eugene a delmar aia architect
850 Sligo Ave. Silver Spring Md. 20910 Tel. 585-8300

job no. 77-1
scale 1/8" = 1'-0"
date 4-5-78
drawn by HC
checked VJT

E2

NOTE: ALL CEILING DIFFUSERS, REGISTERS, GRILLES IN BASEMENT CEILING TO BE CENTERED ACCURATELY IN CEILING TILES. SEE ARCHT. DWGS. FOR REFLECTED CEILING PLAN.

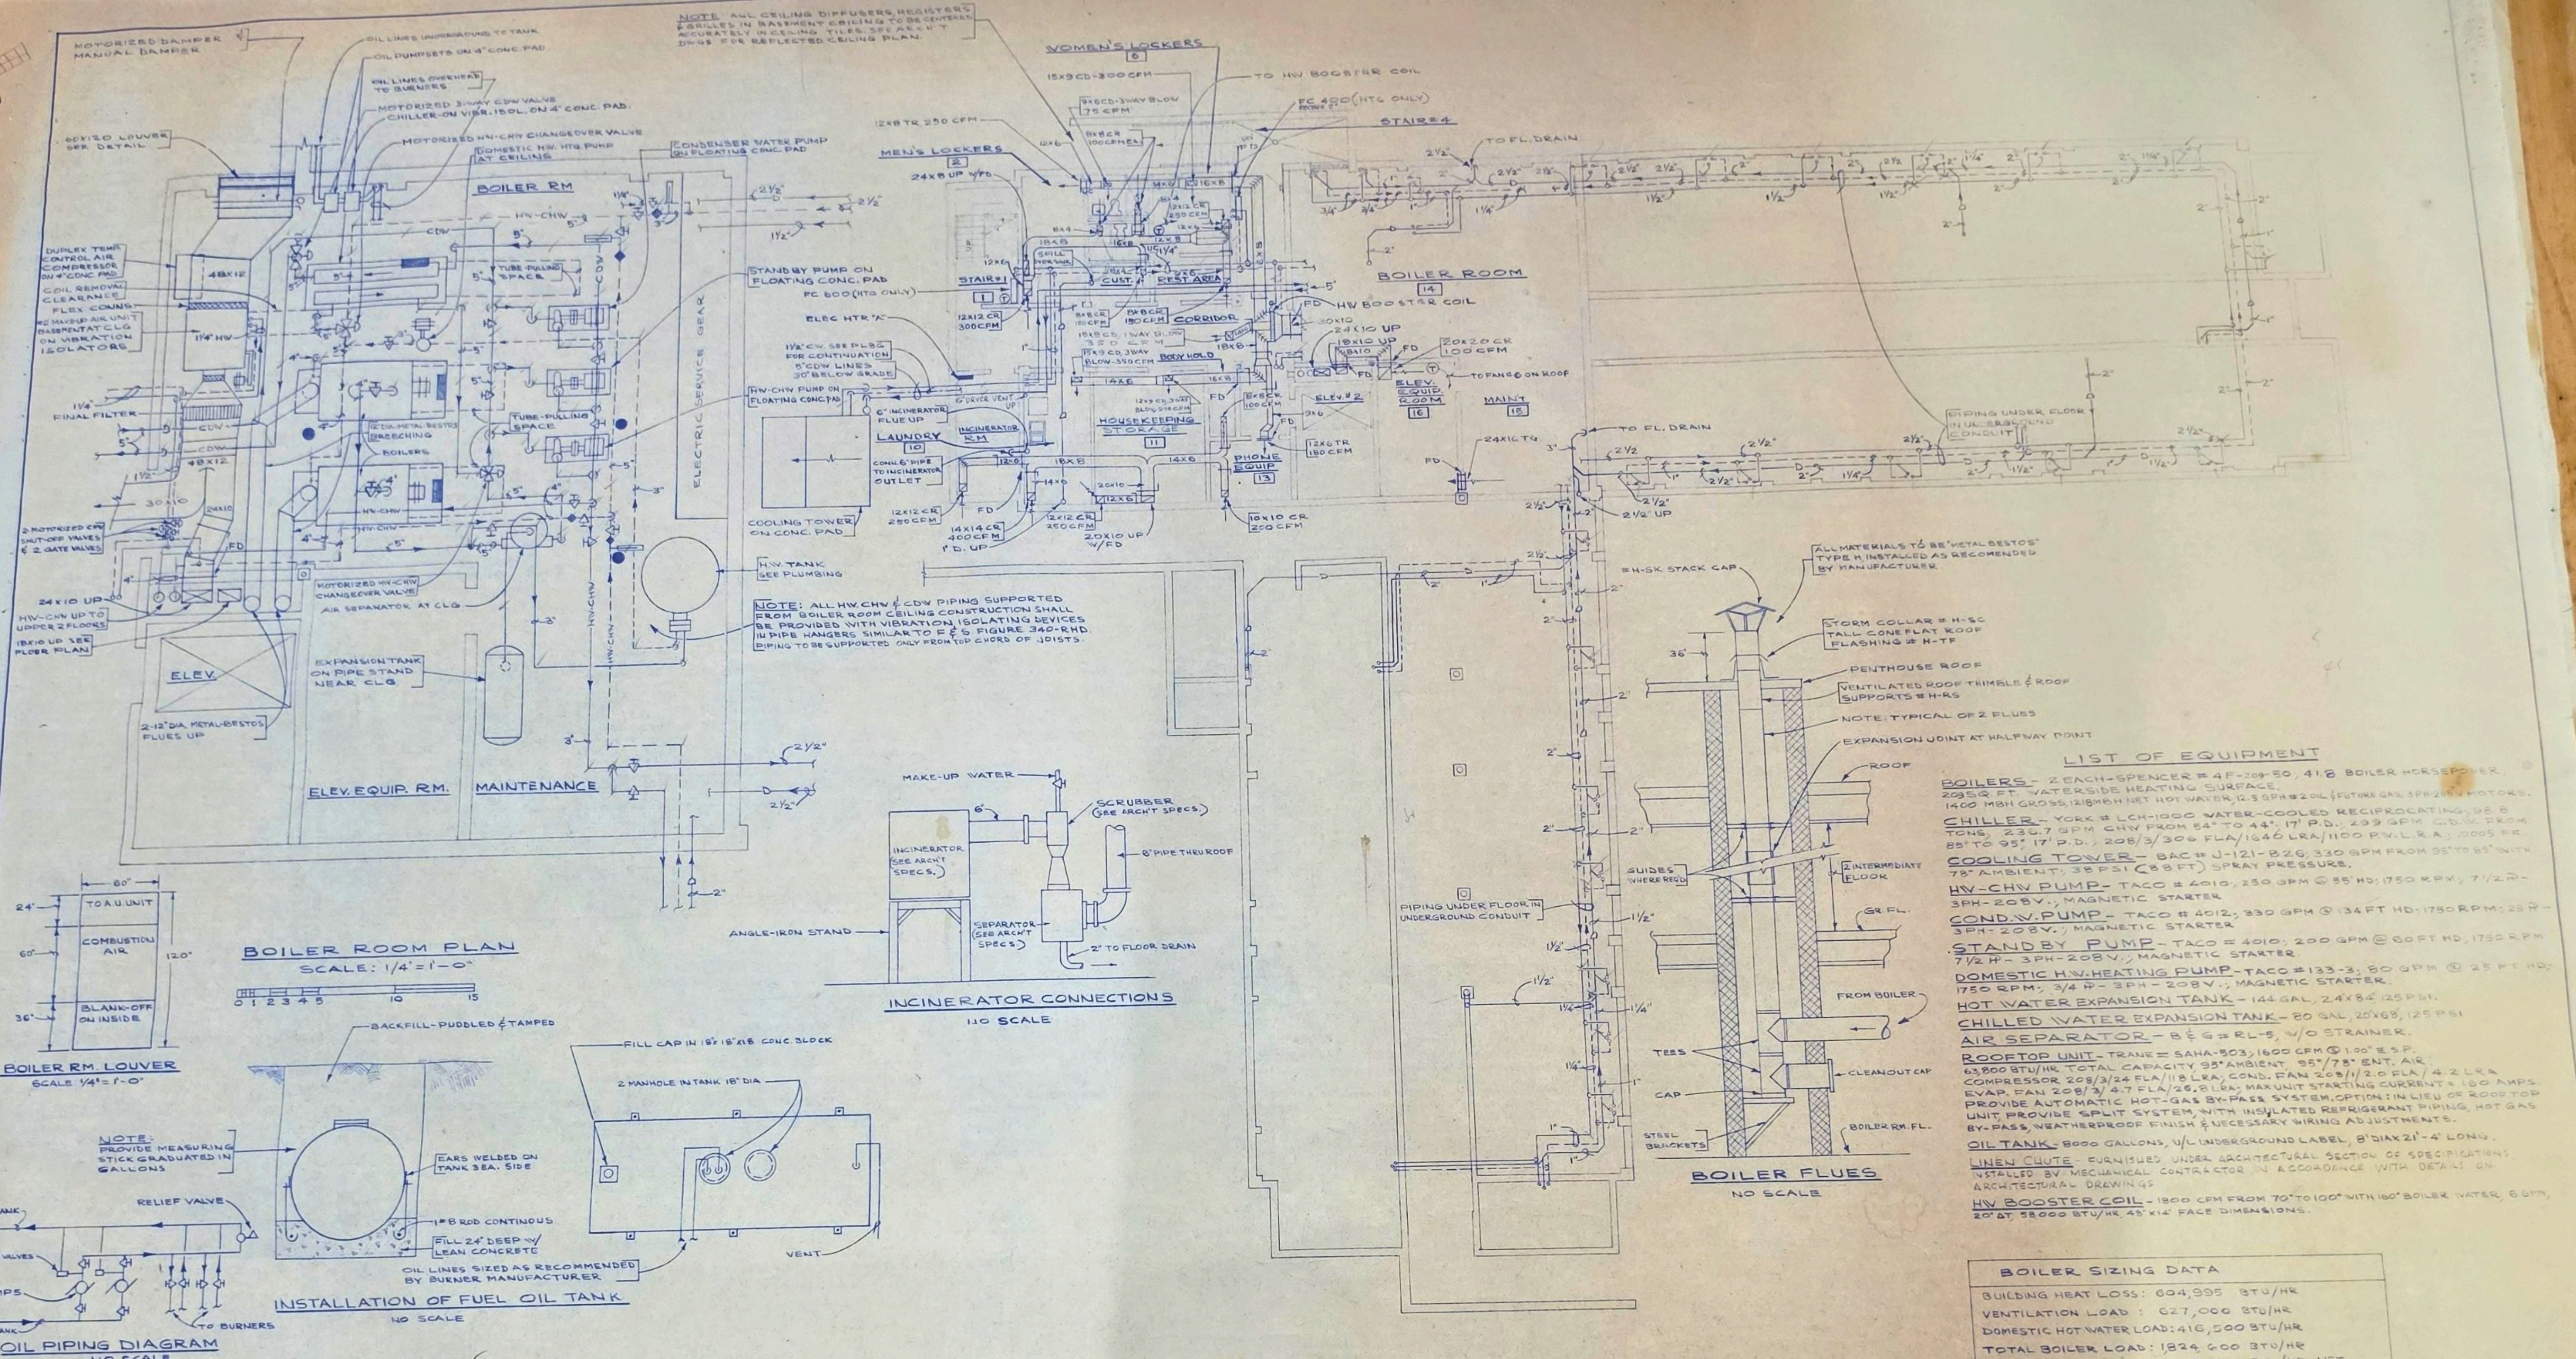

AIR HANDLING UNIT SCHEDULE											
UNIT	TYPE	CFM	CFM OUTSIDE AIR	TSP	MAX FPM	MAX COIL VEL	MIXING BOX	FACE BYPASS	FILTER BOX TYPE	HEATING COILS	COOLING COIL
										ELECTRIC	HOT WATER
MAKE-UP UNIT #1	HORIZONTAL (MAX 24" HIG CAB)	3900	3900	1.75	2000	670	NO	NO	ANGLE	75KW-3PH-208V, 6 STEPS, 0" ENT. AIR	NONE
#2	HORIZONTAL	3300	3300	2.00	1800	550	NO	NO	ANGLE	42KW-3PH-208V, 3 STEPS, 0" ENT. AIR, PRE-HEAT POSITION	NONE

DRAWINGS AND SPECIFICATIONS AS INSTRUMENTS OF SERVICE ARE THE PROPERTY OF THE ARCHITECT. WHETHER THE WORK FOR WHICH THEY ARE MADE BE EXECUTED OR NOT, AND ARE NOT TO BE USED OR COPIED ON OTHER WORK EXCEPT BY WRITTEN AGREEMENT WITH THE ARCHITECT.

CONTRACTOR TO VERIFY ALL DIMENSIONS AND CONDITIONS IN THE FIELD BEFORE PROCEEDING WITH THE WORK.

ROCKVILLE NURSING HOME INC
301 ADCLARE ROAD ROCKVILLE, MARYLAND

eugene a delmar aia architect
850 Sligo Ave. Silver Spring Md. 20910 Tel. 585-8300

job no. 77-1
scale 1/8" = 1'-0"
date 4-2-74
drawn by J.E.
checked M.W.







H1

ELECTRIC HEATER SCHEDULE					
HEATER	TYPE	WATTS	VOLTS	PHASE	CONTROL
A	BERKOWITZ 2000-A SURFACE HTD. ON WALL	2000	208	1	SELF CONTAINED @
B	BERKOWITZ 750-B SURFACE HTD. ON WALL	750	120	1	WALL SWITCH
C	BERKOWITZ 1000-C SURFACE HTD. ON WALL	1000	208	1	SELF CONTAINED @
D	BERKOWITZ 3000-D SURFACE HTD. ON WALL	3000	208	1	SELF CONTAINED @

NOTE: SEE SECTIONS FOR SELECTED CEILING PLAN FOR EXACT LOCATION OF CEILING HEATERS.

FILTER SCHEDULE					
SYSTEM	PRE-FILTER	LOCATION	FINAL FILTER	SIZE	CFM
MAKE-UP #1	IN A.H. UNIT	554 FT.	2	24"X24"X12"	3900
MAKE-UP #2	IN A.H. UNIT	554 FT.	2	24"X24"X12"	3300
FAN #7	FAN INLET DUCT	454 FT.	2	24"X12"X12"	1800
FAN #10	EXHAUST DUCT TO MATCH W. VENT (2)	ROOMS	1 EACH	12"X12"X12"	200
ROOFTOP UNIT	UNIT INLET DUCT	454 FT.	2 EACH (TOTAL)	12"X12"X12"	500

ELECTRIC DUCT COIL SCHEDULE					
COIL	SIZE	KW	PHASE	VOLTS	STEPS OF CONTROL
1	12"X8"	4	3	208	2
2	12"X8"	4	3	208	2
3	24"X8"	10	3	208	3
4	24"X8"	10	3	208	3

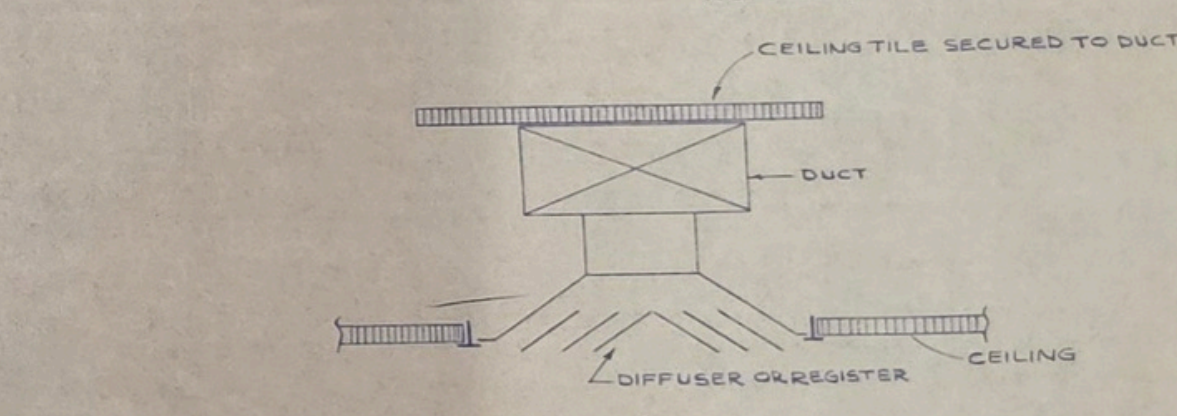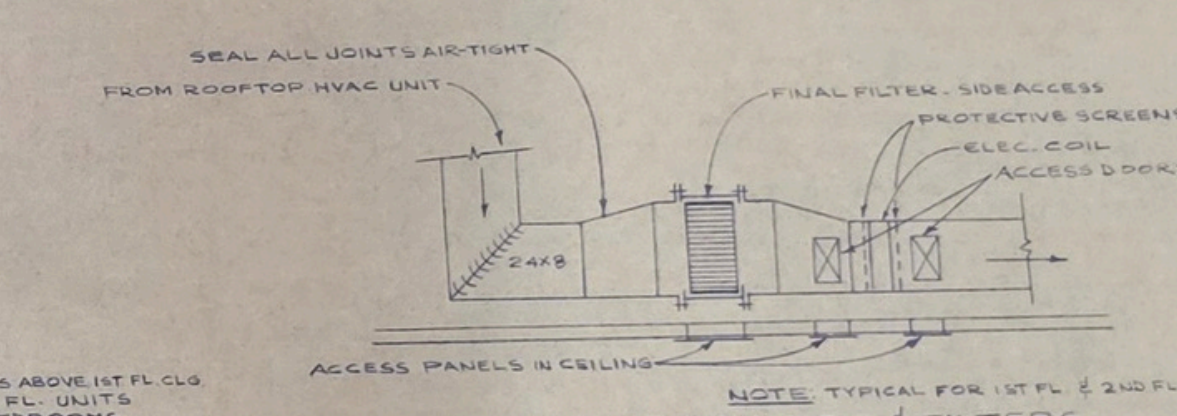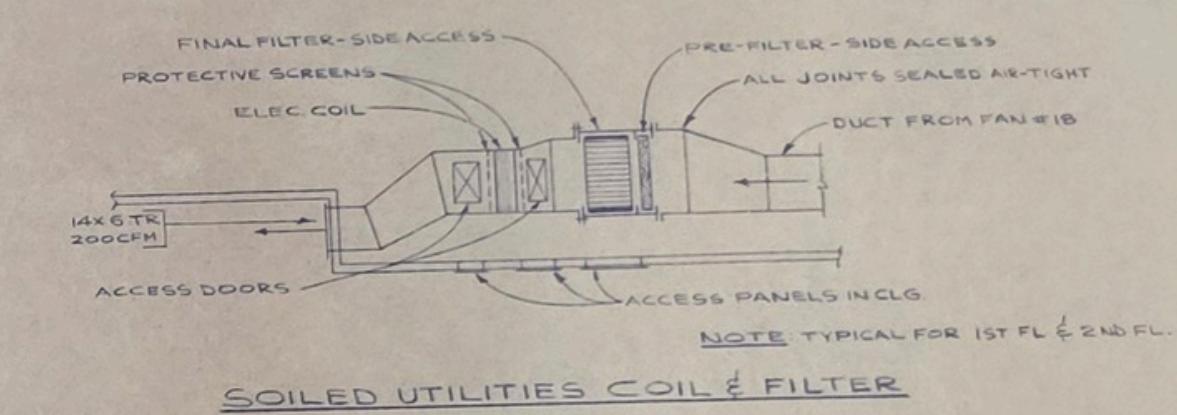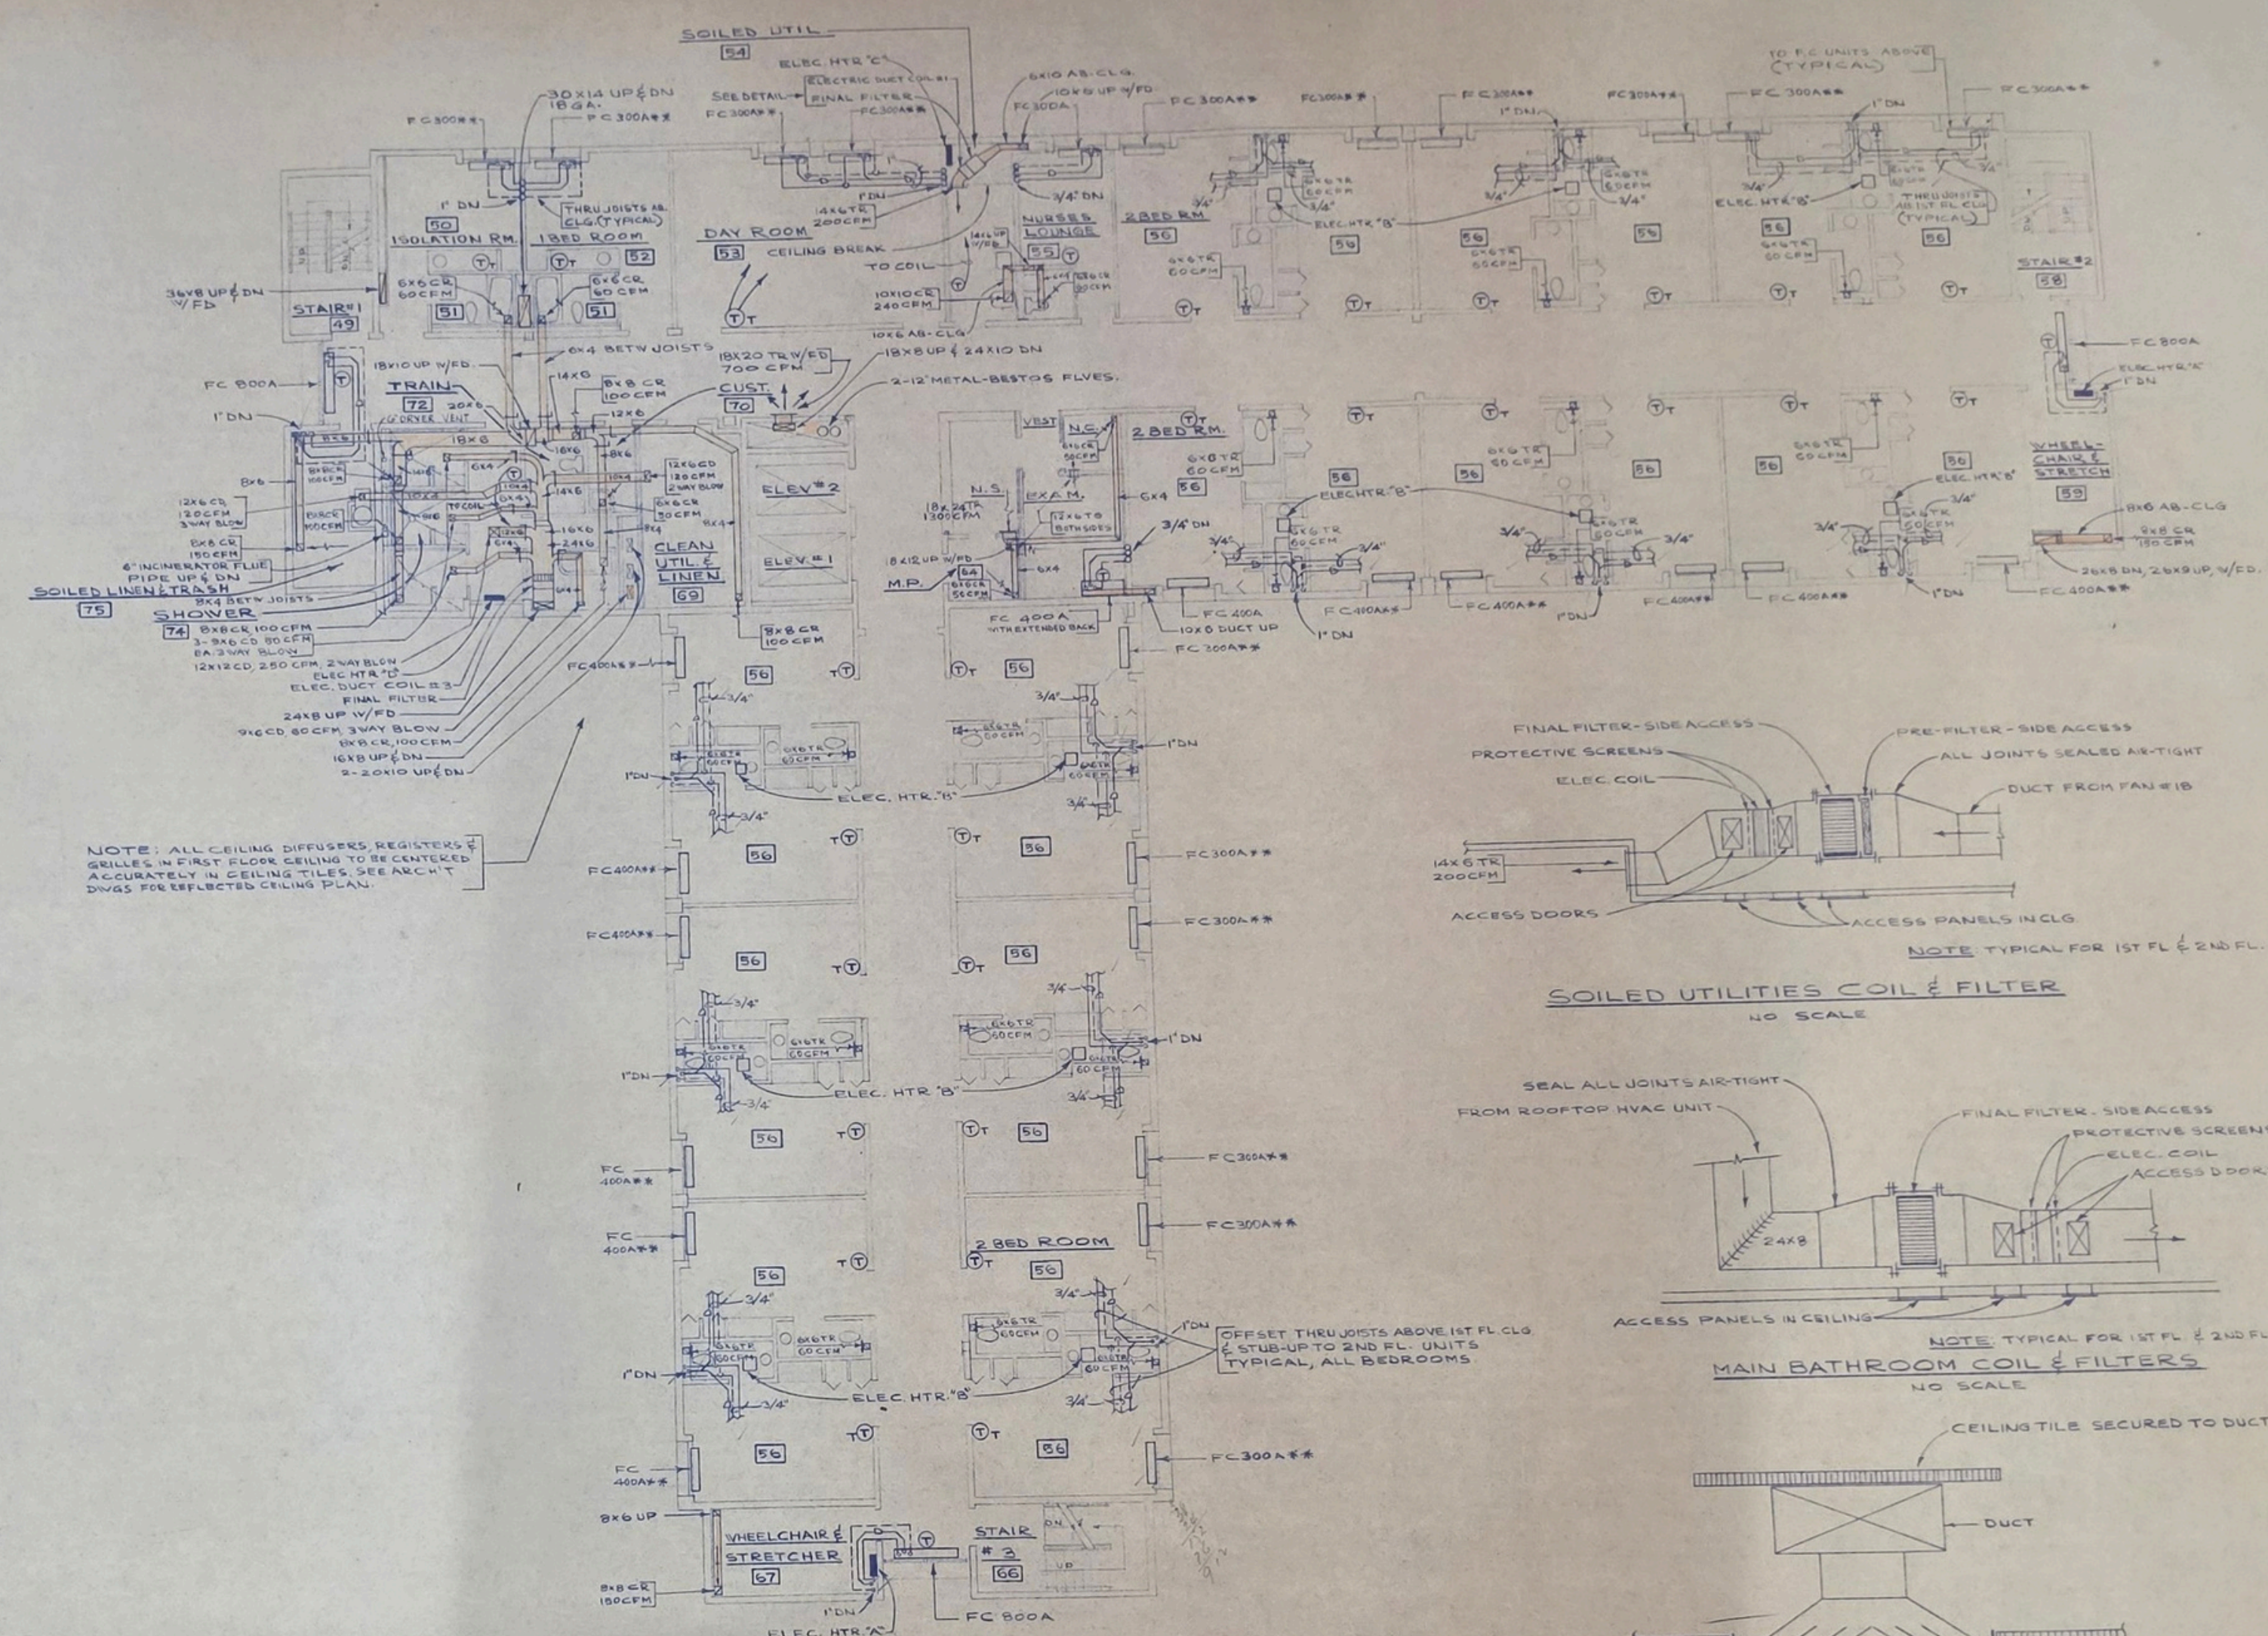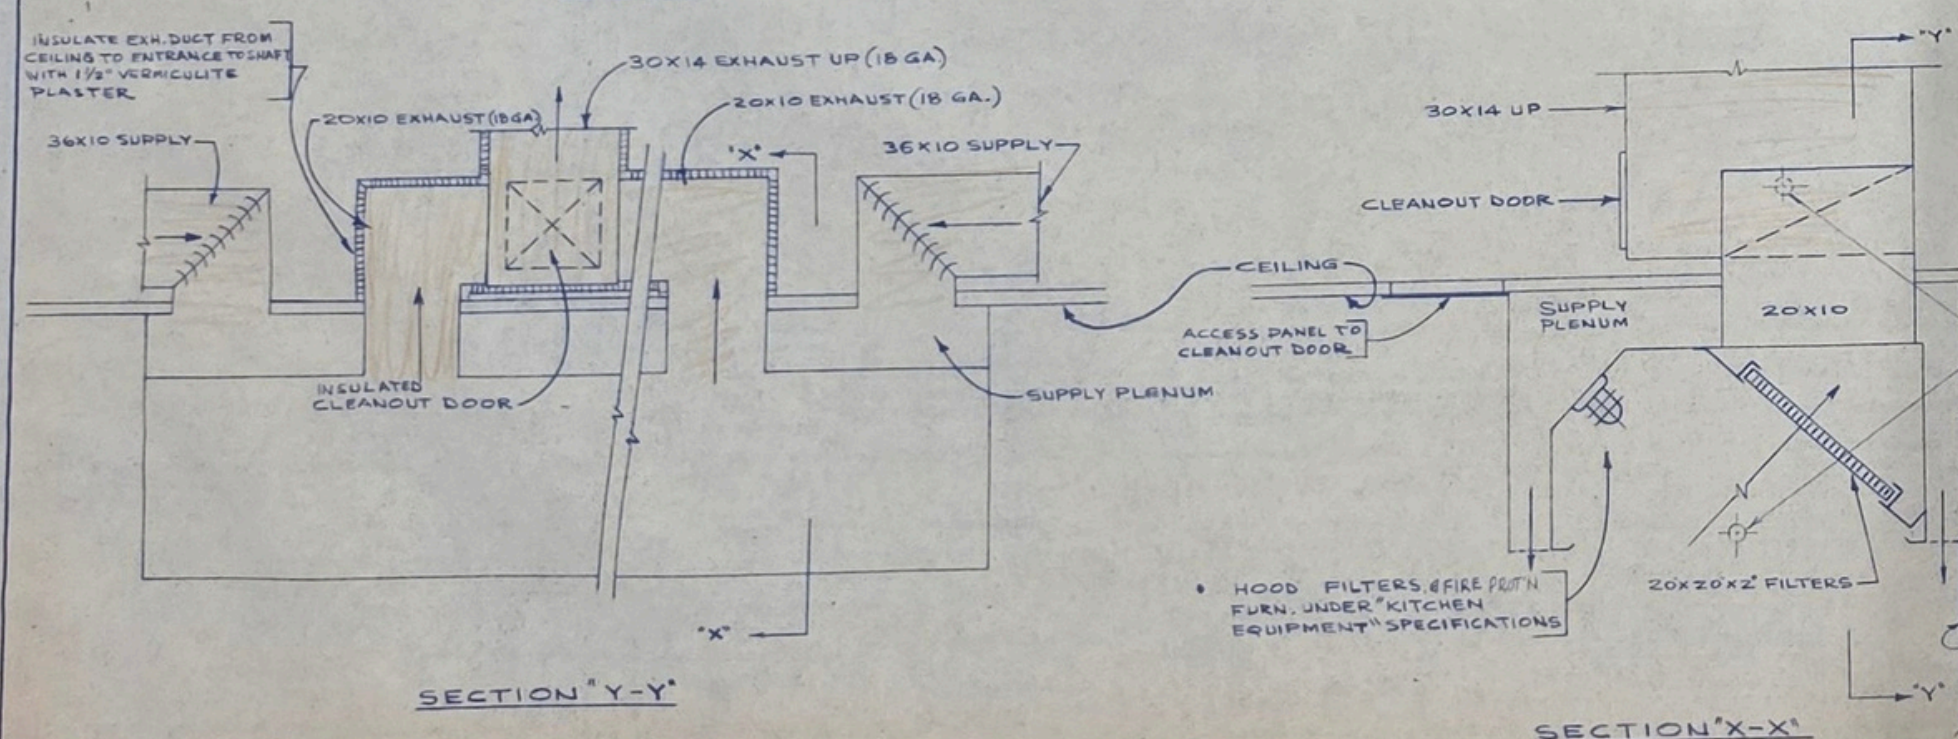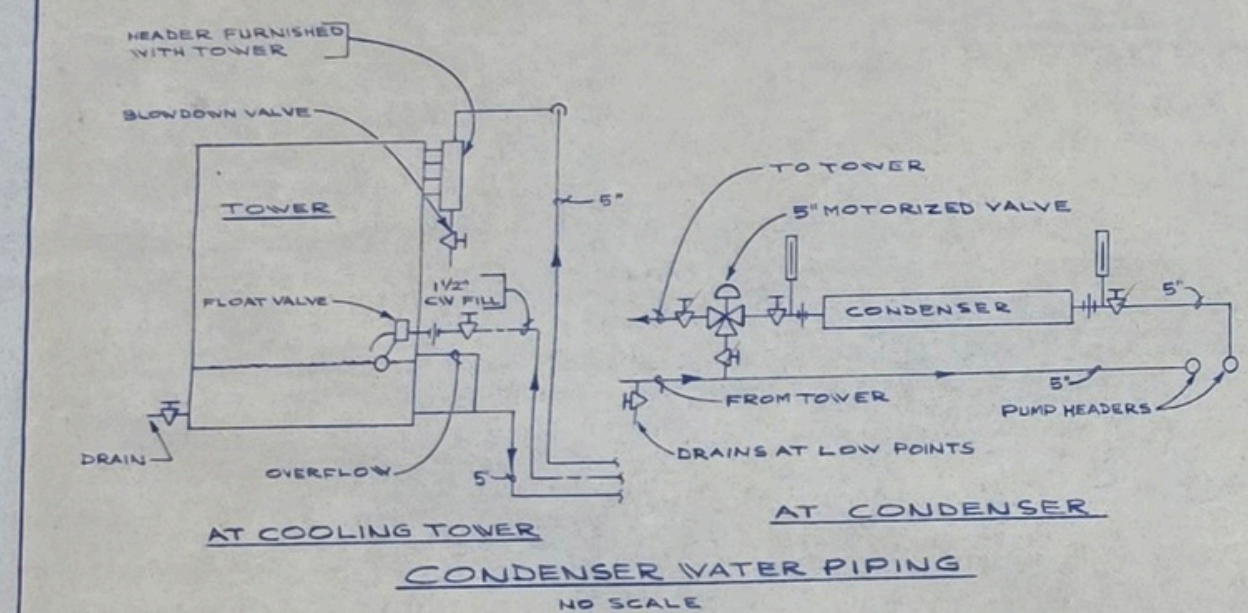

ROCKVILLE NURSING HOME INC
 301 ADCLARE ROAD ROCKVILLE, MARYLAND
eugene a delmar aia architect
 850 Sligo Ave. Silver Spring Md. 20910 Tel. 585-8300

HUD-33
 job no. 11-1
 scale 1/8" = 1'-0"
 date 4-2-74
 drawn by J.E.
 checked H3

PANEL A-2

CIRCUIT	BRANCH CIRCUIT BREAKERS	CONDUCTOR	CONDUIT
---------	-------------------------	-----------	---------

[illegible]

TS, 3 PHASE, 4 WIRE, 2

CIRCUIT	BRANCH	CIRCUIT BREAKERS	CABLE	WIRING	CONDUIT
---------	--------	------------------	-------	--------	---------

[illegible]

VOLTS, 3 PHASE, 4 WIRE

	BRANCH CIRCUIT BREAKERS	CABLES	CONDUITS	
--	-------------------------	--------	----------	--

30				30%	10			CLEANING & MAINT.

2 VOLTS, 3 PHASE, 4 W

1	2	3	466
---	---	---	---	---	---	---	---	---	----	----	-----	-----	
[illegible]

22

 
SCALE: $\frac{3}{8}'' = 1' - 0$

FIRST FLOOR - ELECTRICAL

E3

E3

SCALE: $\frac{1}{8}'' = 1'-0''$



PANEL A3

TYPE "NQOB," 208/120 VOLTS, 3 PHASE 4 WIRE, 225 A MAX NS LOGS ONLY

UNIT	BRANCH	CIRCUIT BREAKER	VOLTS	WATTS	SEPN
NUMBER	FILE	FRAME	TRIP	SIZE	
13		20A	20A	#12	0X
15					0X
THRU 20					0X
26, 19, 20					0X
31, 42		30A	30A	#10	5X
32, 34					#12
35, 40		20A	20A	#12	1X
37, 38			20A		1X
39		40A	40A	#10	5X
40					5X
43		30A	30A	#12	5X
47					5X

PANEL C-3

TYPE "NA1B" 208/120 VOLTS, 3 PHASE 4 WIRE 225A MAINS LUGS ON

POLE NUMBER	BRANCH	CIRCUIT	BREAKERS	CONDUCTOR	CONDUIT	SERVING
	POLE	FRAME	TRIP	SIZE	SIZE	
1, 3	1	100A FA	30A	#10	3/4"	TOILET HEATERS
2	2		20A	#12		FAN COIL UNITS
4 THRU 18	2					FAN COIL UNITS
19	2					ELECTRIC HEATER
20	3					DUCT HEATER 600W
21	3		40A	#8		DUCT HEATER 600W

PANEL B

TYPE "NQOB", 208/120 VOLTS, 3 PHASE, 4 WIRE, 225A MAINS LUGS 0

CIRCUIT NUMBER	BRANCH	CIRCUIT	BREAKER	CONDUCTOR	CONDUIT	SERVING
1 THROUGH	POLE	FRAME	TRIP	SIZE	SIZE	
		50A	Q	20A	#12	8X LIGHTS
6 THROUGH 22					#8	8X RECEPTACLES
23 THROUGH 27						1 PAIR COIL UNIT
28			30A			SPACES
30			30A	#10		SPACE CLEANING RECEPTAC

PANEL D

TYPE "NA1B", 208/120 VOLTS, 3 PHASE, 4 WIRE, 225 A MAINS, LUGS

CIRCUIT	BRANCH	CIRCUIT	BREAKERS	CONDUIT	CONDUIT	SERVING
NUMBER	POLE	FRAME	TRIP	SIZE	SIZE	
1,3,5	1	100A	FA	30A	#10	3/4"
2,4,6	1	100A		20A		
THRU 18	2				#12	
21					#12	
20,22,23						
24	1		30A	#10		

ANNUNCIATOR NOTES

- 1 PROVIDE BACK BOARD AND STAINLESS STEEL 2" ZIN TO FIT FILLATED SPACE. MOUNTING HEIGHT AS SHOWN
- 2 PANEL TO BE ORAL PERLIGLAS WITH ALL OUTLINE SCAINED IN BLACK AND MOUNTED BEHIND CLEAR PERLIGLAS PANEL.
- 3 PILOT LIGHT SHALL BE 3/4" DIA WITH INDICATED COLOR AND BE GREEN AND 1/2" DIA BELL
- 4 ACTIVATION OF SPRINKLES FLOW SHALL SOUND FIRE ALARM AND LIGHT SPRINKLER FLOWMABLE LIGHT
- 5 PROVIDE PERLIGLAS STEPS WITH SHIELDED CLEAR LAMP BEHIND LAMP SHALL LIGHT RED FLOOD
- 6 IDENTIFICATIONS SHALL BE SCAINED AND FILLED WITH BLACK

HUD-38


ROCKVILLE NURSING HOME INC
301 ADCLARE ROAD ROCKVILLE, MARYLAND

eugene a delmar aia architect
850 Sliqo Ave. Silver Spring Md. 20910 Tel. 585-8300

job no 72-1
scale 1/2" = 1'
date 4-2-74
drawn by H.G.
checked V.J.T.

E4


COMM. NO. 72-1331

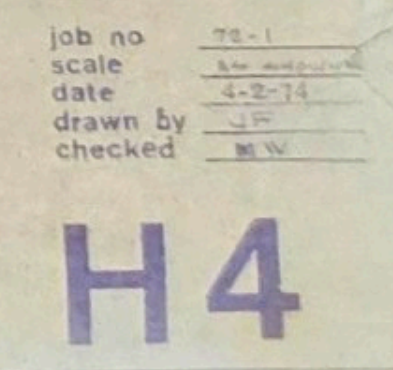

HUD-34

BASEMENT FLOOR PLAN - ELECTRICAL

SCALE: 1/8" = 1'-0"

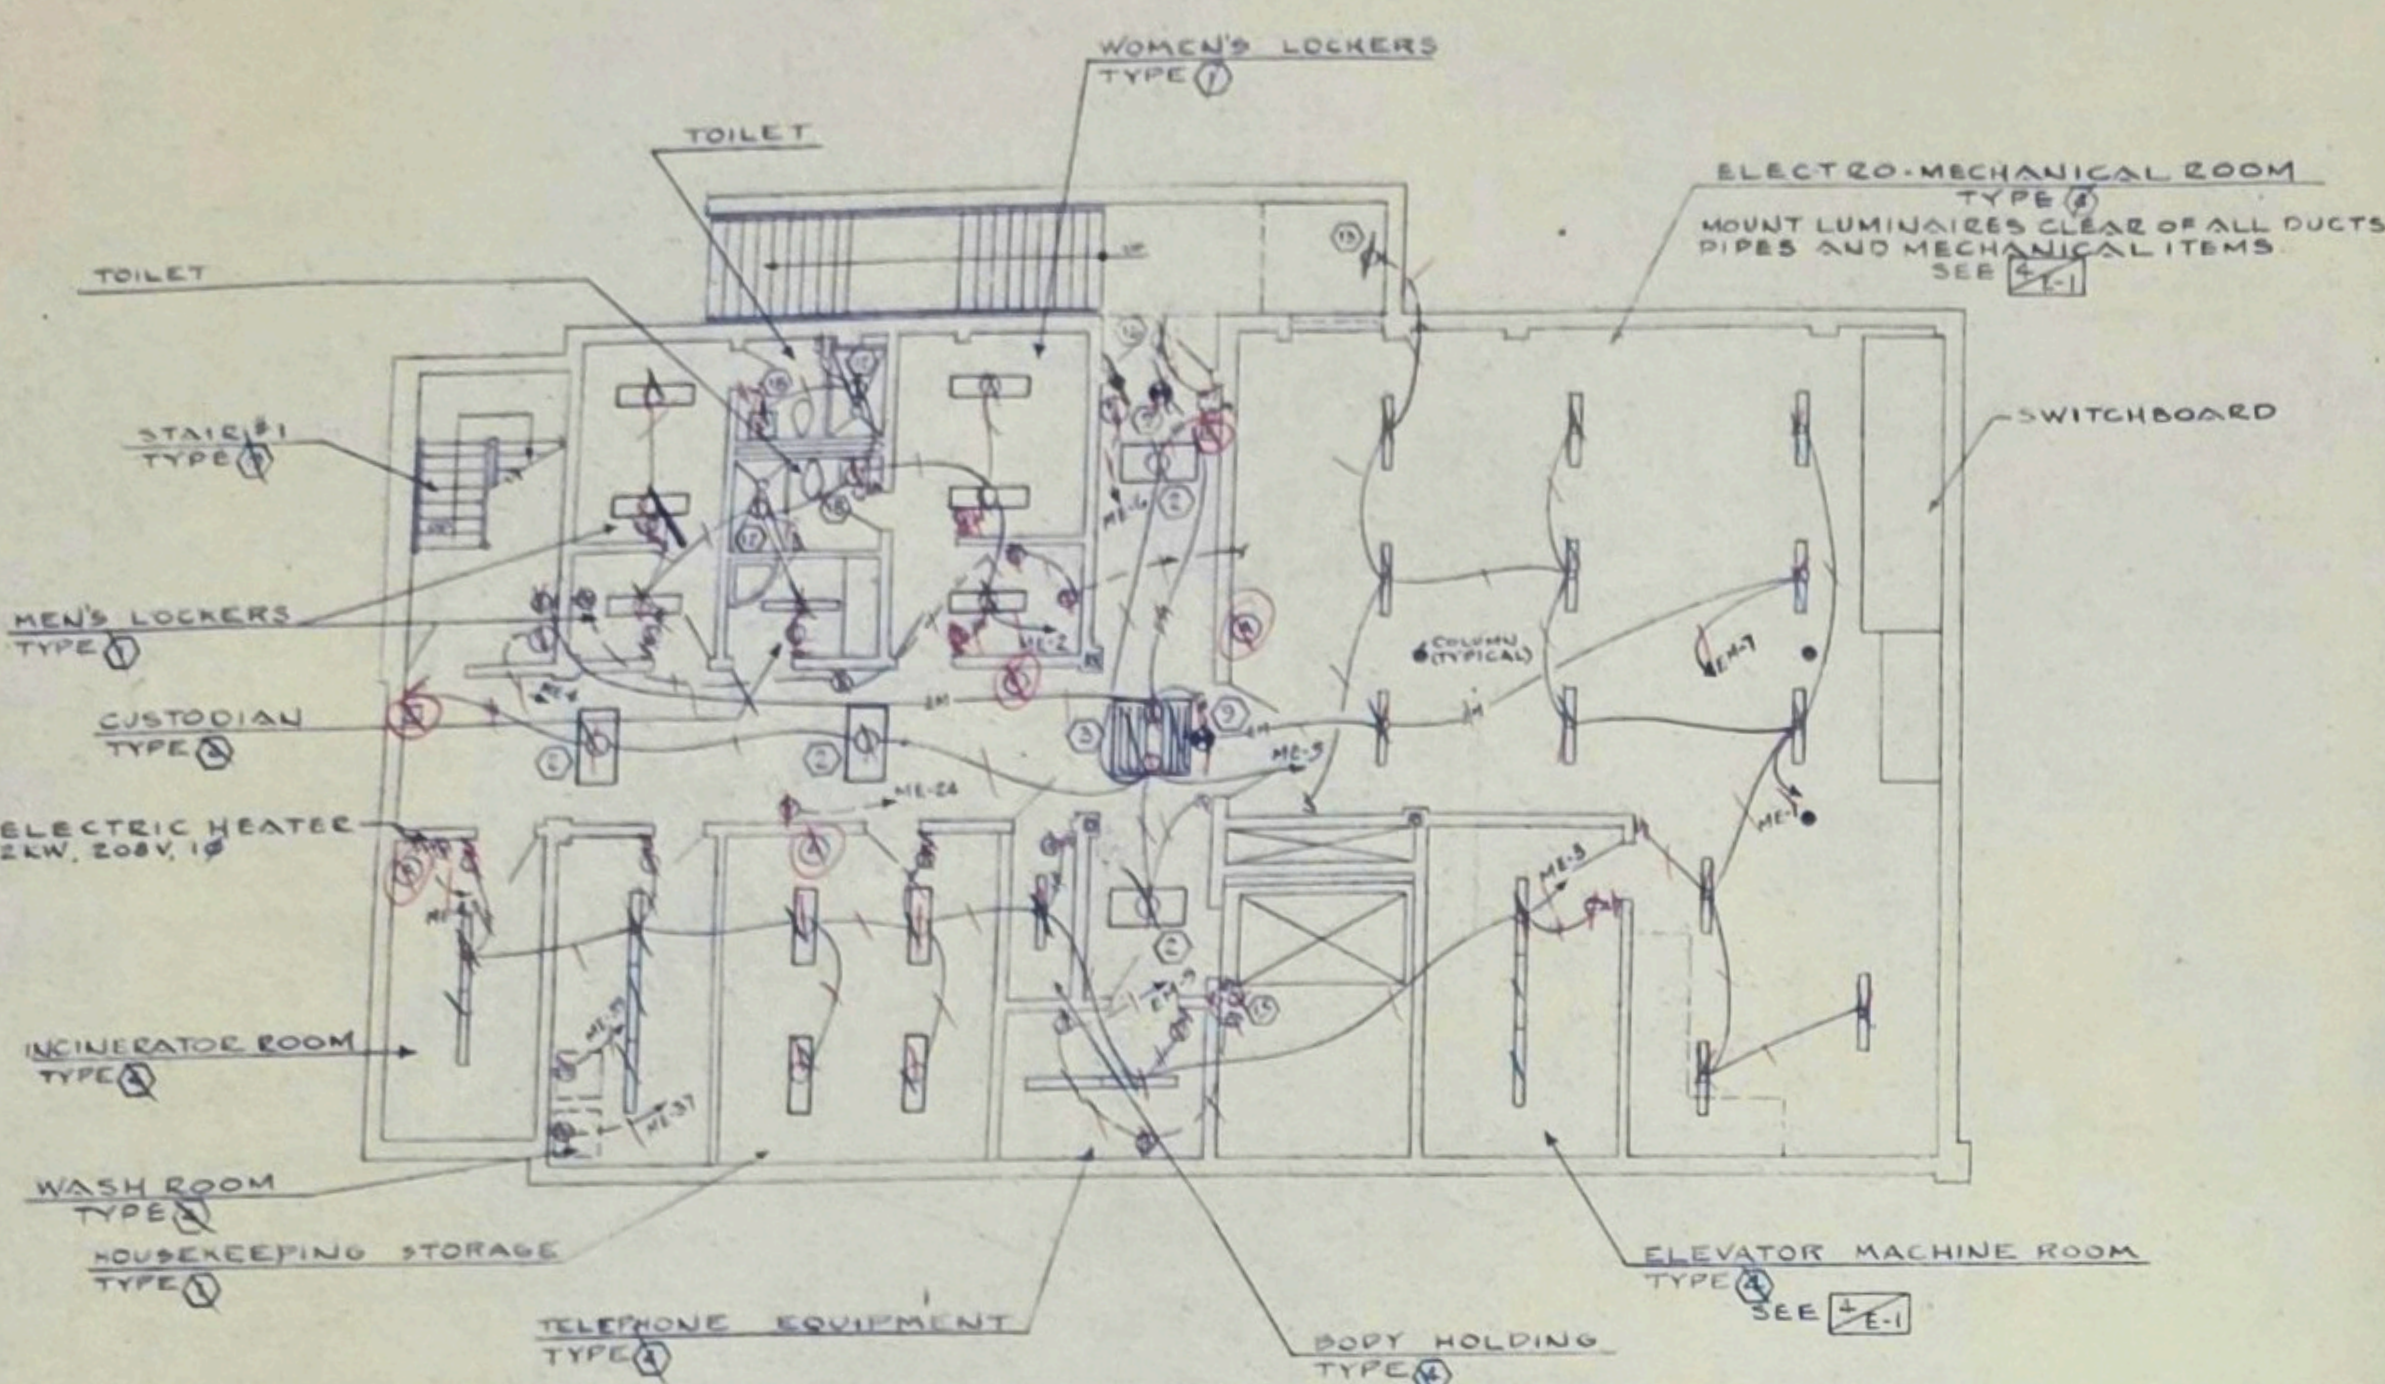

GENERAL NOTES


- RECORD DRAWINGS - SEE ARCHITECTURAL SPECIFICATIONS.
- ALL OUTLET BOXES SHALL BE LOCATED ON CLEAR WALLS, NOT IN CHALK, OR OVERHEADS, SHELVES, BEHIND DOORS, CABINETS, ETC. ITEMS IMPROPERLY LOCATED SHALL BE RELOCATED AT CONTRACTOR'S EXPENSE.
- ALL SURFACE MOUNTED ELECTRICAL EQUIPMENT INCLUDING PANELS, DISCONNECT SWITCHES AND ACCESSORIES SHALL BE MOUNTED ON UNISTEEL OR ZODDER.
- BRANCH CIRCUITS OVER 100' SHALL BE #10 AWG MINIMUM.
- PROVIDE 3/4" EMPTY CONDUIT FOR EACH SINGLE POLE SPACE IN ALL RECESSED PANELS. TURN OUT ABOVE CEILING CAP AND TAG. PROVIDE ACCESS PANELS IN ALL CEILING NOT READILY ACCESSIBLE OR WHERE DIRECTED.
- ALL PANELBOARDS AND DISCONNECT SWITCHES SHALL HAVE COPPER BUS AND APPURTENANCES.
- CONDUITS INSTALLED IN EARTH OR BELOW VAPOR BARRIERS SHALL BE PAINTED TWO COATS OF BLACK ASPHALTUM.
- ALL RACEWAYS SHALL BE CAPED UNTIL CONDUCTORS ARE INSTALLED.
- HORIZONTAL RACEWAY BUS SHALL NOT BE INSTALLED IN WALLS UNLESS SPECIFICALLY AUTHORIZED.
- ALL ELECTRIC OUTLETS AND ACCESSORIES FURNISHED WITH EQUIPMENT AND/OR EXISTING EQUIPMENT REUSED AND RELOCATED SHALL BE CONNECTED AND ENERGIZED BY THE ELECTRICAL CONTRACTOR.
- OUTLET MOUNTING HEIGHTS SHALL BE ADJUSTED TO NEAREST MODULAR JOINT.
- CONTRACTOR SHALL VISIT EXISTING SITE AND DETERMINE CONDITIONS WHICH MAY EFFECT HIS BID.
- CONTRACTOR AND LUMINAIRE MANUFACTURER ARE RESPONSIBLE FOR PROVIDING PROPER TERM, MOUNTINGS, ETC TO SUIT ACTUAL ARCHITECTURAL CEILING INSTALLATION.
- ALL MICA NAME PLATES SHALL BE RECEIVED TO EQUIPMENT - GLUES ARE NOT ACCEPTABLE.
- ALL PANELBOARDS SHALL BE MINIMUM 8" DEEP.
- EQUIPMENT, ITEMS AND APPURTENANCES REQUIRING SPECIAL MAINTENANCE AND/OR MANUAL OPERATION SHALL NOT BE INSTALLED IN INACCESSIBLE LOCATIONS OR LOCATIONS WHICH WILL BECOME INACCESSIBLE.
- TELEPHONE SYSTEM: PROVIDE AND INSTALL OUTLET BOX AND COVER AT EACH OUTLET INDICATED. PROVIDE AND INSTALL 1" CONDUIT FROM EACH OUTLET TO TELEPHONE SPACE. TELEPHONE COMPANY TO INSTALL ALL CABLES. SEE 1-15.
- SOUND SYSTEM: PROVIDE AND INSTALL THE FOLLOWING EQUIPMENT AND APPURTENANCES TO FORM A COMPLETE AND FUNCTIONING PAGING AND ANNOUNCEMENT SOUND REINFORCING SYSTEM:
A- AMPLIFIER: UNIVERSALITY #1000-1000 SHELF MOUNTED IN CABINET.
B- MICROPHONE: ELECTRO-VOICE #615L DESK TYPE.
C- SPEAKERS: SOUNDOLIER #C-5725 WITH WHITE GRILLE #51-B AND #95-B BACK BOX.
D- CABLE: MOHAWK #1665 TWO CONDUCTOR, SHIELDED #18 RACEWAY 3/4" MINIMUM.
E- MANUFACTURERS: DUKANE OR ALTEC WILL BE CONSIDERED.
- DIMMER PANEL SHALL BE MAJOR #60030/202 WITH 3 POLE, 60A, FA MAIN CIRCUIT BREAKER. ALL COMPLETE PANEL SHALL BE RECESSED IN WALL. REMOTE STATION 50 SHALL BE MAJOR #201 COMPLETE. MANUFACTURERS: KLEIGLE OR HUB WILL BE CONSIDERED.
- RECESSED FLUORESCENT LUMINAIRES SHALL BE INSTALLED PRECISELY IN CEILING GRID. RECESSED INCANDESCENT LUMINAIRES SHALL BE INSTALLED IN THE EXACT CENTER OF CEILING TILES. SEE ARCHITECTURAL REFLECTED CEILING PLANS. CONSULT WITH ARCHITECT BEFORE INSTALLING LUMINAIRES.
- INDICATING CLOCK SHALL BE SIMPLEX #TYPE 48 WITH HANDS MOUNTED AS DIRECTED. COLOR & DIAMETER TO BE SELECTED BY ARCHITECT.
- FOR OUTSIDE ELECTRICAL APPURTENANCES SEE DWG OUT-1.

SYMBOLS

- | SYMBOL | DESCRIPTION |
|--------|--|
| ○ | INCANDESCENT LUMINAIRE & OUTLET (SEE SCHEDULE) |
| ○ | INCANDESCENT LUMINAIRE & OUTLET (SEE SCHEDULE) |
| ○ | FLUORESCENT LUMINAIRE & OUTLET |
| ○ | LUMINAIRE & OUTLET ON EMERGENCY CIRCUIT |
| ○ | WALL & CEILING EXIT LIGHT CONNECTED TO EMERGENCY CIRCUIT |
| ○ | SINGLE POLE SWITCH & RECEPTACLE WITH REMOTE CONTROLLED |
| ○ | THREE WAY SWITCH |
| ○ | MOTOR RATED SWITCH WITH THERMAL RELEASE FURNISHED BY MECHANICAL CONTRACTOR CONNECTED TO ELECTRICAL |
| ○ | SWITCH & PILOT LIGHT |
| ○ | DUPLEX RECEPTACLE |
| ○ | DUPLEX RECEPTACLE ABOVE WORK TOP |
| ○ | SWITCH & RECEPTACLE COMBINATION |
| ○ | SAFETY LIGHT DUPLEX RECEPTACLE |
| ○ | MICROPHONE |
| ○ | TV OUTLET & RECEPTACLE COMBINATION SEE 1-15 |
| ○ | ELECTRIC HEATER |
| ○ | FAN COIL UNIT |
| ○ | MOTOR BY MECHANICAL CONTRACTOR CONNECTED BY ELECTRICAL CONTRACTOR |
| ○ | MOTOR CONTROLLER BY MECHANICAL CONTRACTOR CONNECTED BY ELECTRICAL CONTRACTOR |
| ○ | DISCONNECT SWITCH |
| ○ | TOILET CEILING ELECTRIC HEATER |
| ○ | INDICATES LUMINAIRE TYPE SEE SCHEDULE 1-15 |
| ○ | UNION BOX SEE SPEC FOR COLOR CODING |
| ○ | SPEAKER AND OUTLET |
| ○ | MOUNTING HEIGHT |
| ○ | SOUND RACEWAY CONCEALED |
| ○ | WALL MOUNTED DOME LIGHT |
| ○ | RED STATION |
| ○ | CLOCK HANGER OUTLET |
| ○ | SINGLE FACE CLOCK |
| ○ | FIRE ALARM HORN OR BELL |
| ○ | FIRE ALARM STRIKING STATION |
| ○ | DOOR ALARM |
| ○ | EMERGENCY CALL BUTTON OUTLET |
| ○ | TELEPHONE OUTLET |
| ○ | ELECTRIC PANEL |
| ○ | ELECTRIC DUCT HEATER |
| ○ | EMERGENCY CIRCUIT |
| ○ | CONDUIT CONCEALED IN WALL OR CEILING |
| ○ | RACEWAY UNDERGROUND, NOT BELOW FLOOR |
| ○ | HOME RUN TO PANEL ARROWS INDICATE NUMBER OF CIRCUITS, CROSS MARKS INDICATE NUMBER OF CONDUCTORS |
| ○ | SMOKE DETECTOR |
| ○ | SPEAKER ALARM CONNECTION |
| ○ | MAGNETIC DOOR HOLDER |
| ○ | TV RACEWAY CONCEALED |
| ○ | 3X CONDUIT |
| ○ | RAIN TIGHT |
| ○ | SIMPLEX 30A RECEPTACLE |
| ○ | KEY SWITCH |
| ○ | CONDUIT UP |
| ○ | CONDUIT DOWN |
| ○ | PB/PL PUSH BUTTON PILOT LIGHT |
| ○ | CONDUIT EXPOSED |
| ○ | NURSE CALL DIRECTIONAL DOME LIGHT |
| ○ | EMPTY CONDUIT |
| ○ | TELEPHONE TERMINAL CABINET |
| ○ | NURSECALL EMERGENCY STATION |
| ○ | DUTY STATION |
| ○ | WIREMOLD #3000 WITH SPECIFIED DUPLEX RECEPTACLES |
| ○ | DUPLEX RECEPTACLE ON EMERGENCY SYSTEM ENGRAVE PLATE "EMERGENCY POWER" |

ELECTRO-MECHANICAL ROOM DETAIL

SCALE: 1/4" = 1'-0"

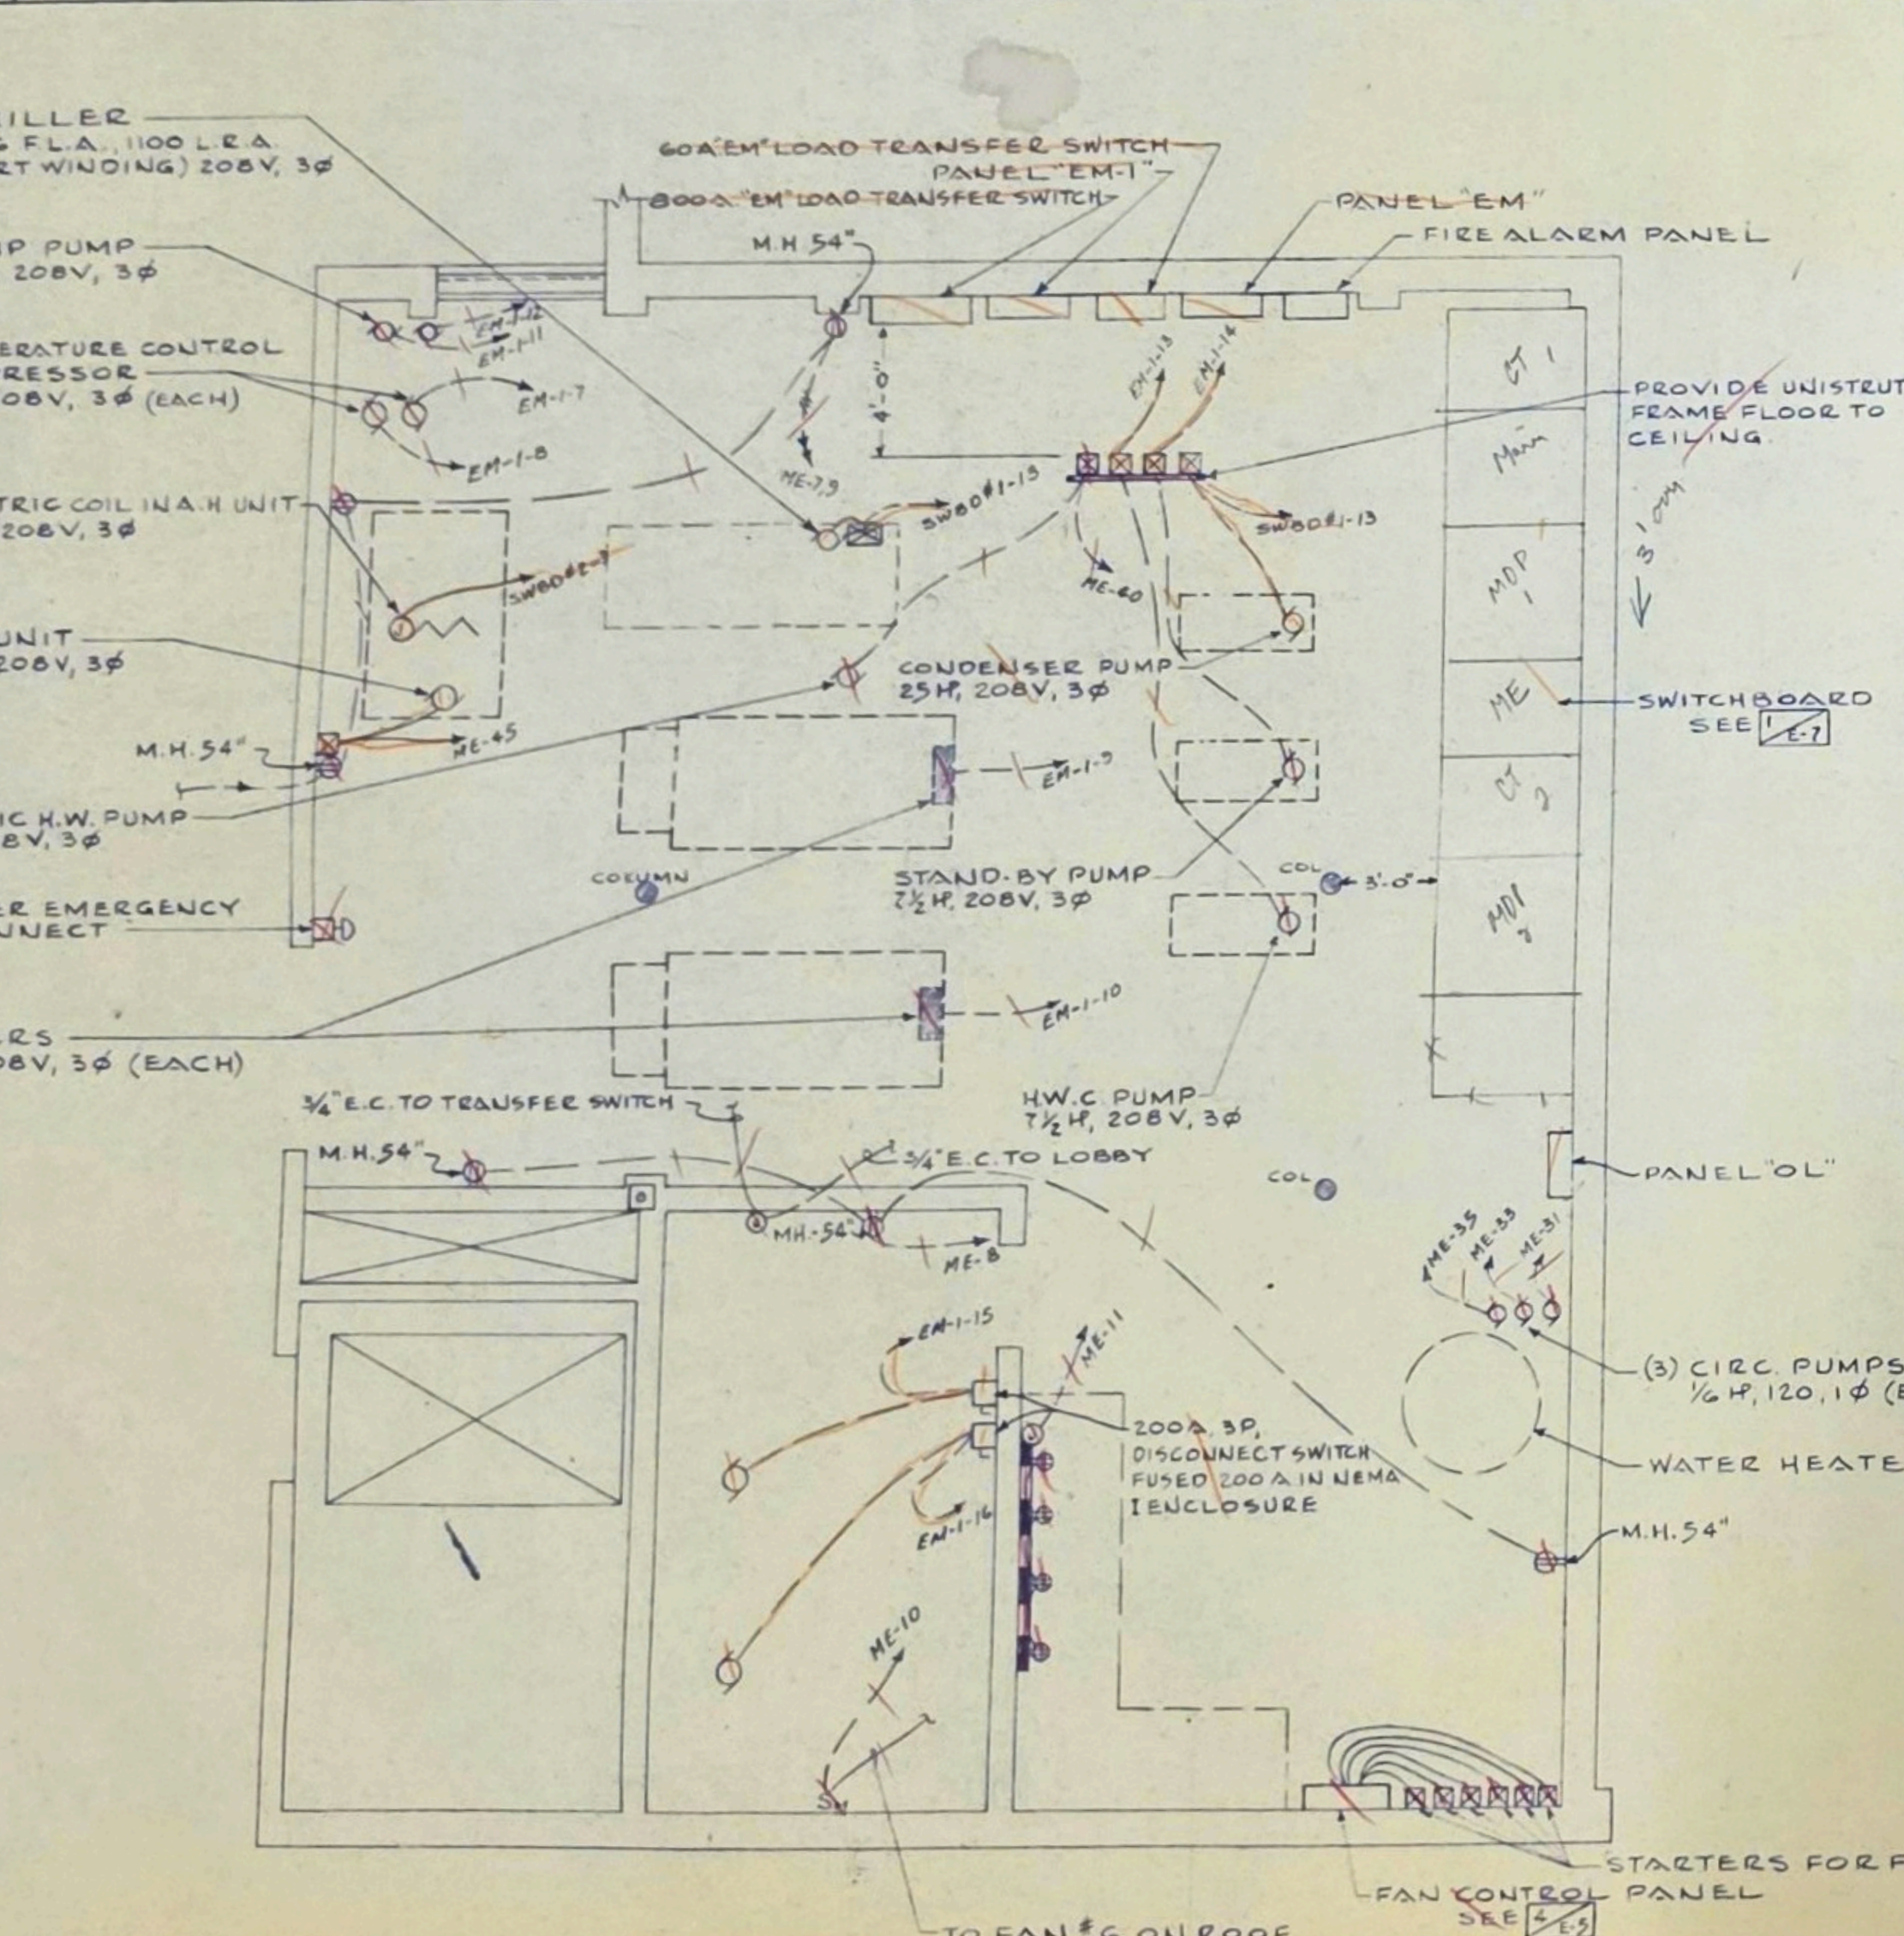

PANEL SCHEDULE

TYPE "N" 120V, 208/120V, 3 PHASE, 4 WIRE, 400A MAINS, LUGS ONLY

CIRCUIT NUMBER	BRANCH	CIRCUIT BREAKER	CONDUCTOR	CONDUIT	SERVING
1, 2, 3, 5	1	100A FA	20A	#12	3/4"
4, 6					LIGHTS
7, 8, 9, 11					FAN COIL UNITS
10, 12					RECEPTACLES
13, 14					FAN #6 & FAN #10
15, 16					FAN #9 & FAN #12
17, 18					FAN #11 & FAN #14
19					FAN #13 & FAN #16
20, 21, 22					FAN #15
23, 24					FAN COIL UNITS
25, 26					SPARE
27, 28					CLEANING RECEPT.
29					FAN #4 & FAN #5
30					FAN #8 & FAN #12
31, 33, 35					FAN #16
36, 43					SPARE
37					CIRCULATING PUMPS
38					ELECTRIC HEATERS
39					WASHER
40					SPARE
41					SPARE
42, 44					SPARE
43					SPARE
45					SPARE
46, 49					SPARE
52, 53					SPARE
50, 51					SPARE

- NOTES:
- DO NOT RUN CONDUITS UNDER BOILER BASES.
 - MAINTAIN 3'-0" CLEARANCE IN FRONT OF ALL ELECTRICAL EQUIPMENT.

BASEMENT FLOOR PLAN & DETAILS - ELECTRICAL


DRAWINGS AND SPECIFICATIONS AS INSTRUMENTS OF SERVICE ARE THE PROPERTY OF THE ARCHITECT. WHETHER THE WORK FOR WHICH THEY ARE MADE BE EXECUTED OR NOT, AND ARE NOT TO BE USED OR COPIED ON OTHER WORK EXCEPT BY WRITTEN AGREEMENT WITH THE ARCHITECT.
 CONTRACTOR TO VERIFY ALL DIMENSIONS AND CONDITIONS IN THE FIELD BEFORE PROCEEDING WITH THE WORK.
COMM NO 72-1331
 7910 WOODMONT AVE.
ROCKVILLE NURSING HOME INC
 301 ADCLARE ROAD ROCKVILLE, MARYLAND
eugene a delmar aia architect
 850 Sligo Ave. Silver Spring Md. 20910 Tel. 585-8300
 HUD-35
 job no. 77-1
 scale 1/8" = 1'-0"
 date 4-2-74
 drawn by H.C.
 checked V.T.
E1

KITCHEN-DISHWASHING AREA VENTILATION DATA:	
VOLUME OF AREA: 1200 CU.FT.	HOOD AREA: 48 SQ.FT.
AIR CHANGES = 15.00 CFM	AIR EXHAUSTED = 800 CFM
AIR EXHAUSTED = 2400 CFM	AIR SUPPLIED = 3200 CFM
AIR SUPPLIED = 2000 CFM	


NOTE: ALL CEILING SPOUSERS, REGISTERS & GRILLED
NEEDING FLOOR CEILING TO BE EQUIPPED WITH EXTENDED
PANELS WITH FACTORY WHITE ENAMEL FINISH TO FIT
24" X 24" LAY-IN TEE-BARS EXCEPT IN ROOMS WITH
OR DRY-WALL CEILING. SEARCH TUNGS FOR REFLECTED
CEILING PLAN.

1. ALL DUCT WORK TO BE MADE FROM FIELD DIMENSIONS
2. SEE SPECIFICATIONS FOR "AS BUILT" DRAWING FURNISHED BY CONTRACTOR
3. CONTRACTOR SHALL VERIFY LOCATION OF ALL THERMOSTATS BEFORE
ROUGH-IN FOR SAME. THERMOSTATS SHALL CLEAR DOOR SWELLS,
FURNITURE & SHYLVES, ETC. THERMOSTATS SHALL BE RELOCATED
AT NO COST TO OWNER IF NOT COMPLYING WITH THE ABOVE.
4. CONTRACTOR SHALL PROVIDE WRITTEN CERTIFICATION THAT ALL MECHANICAL SYSTEMS HAVE BEEN TESTED AND THAT
THE INSTALLATION PERFORMANCE OF ALL SYSTEMS CONFORM TO THE REQUIREMENTS OF THE PLANS & SPECIFICATIONS.
5. CONTRACTOR SHALL PROVIDE ALL NECESSARY BASES FOR
EQUIPMENT NOT SHOWN ON STRUCTURAL OR ARCHITECTURAL PLANS.
6. SEE ARCHITECTURAL REFLECTED CEILING PLANS FOR EXACT LOCATION OF ALL CEILING
DIFFUSERS, REGISTERS & GRILLES.


ALL UNITS ARE
FREE STANDING AT
FLOOR UNLESS AT
OTHER WISE NOTED
ON PLANS. RACES
UNIT SHOULD HAVE
OVERLAP FLANK

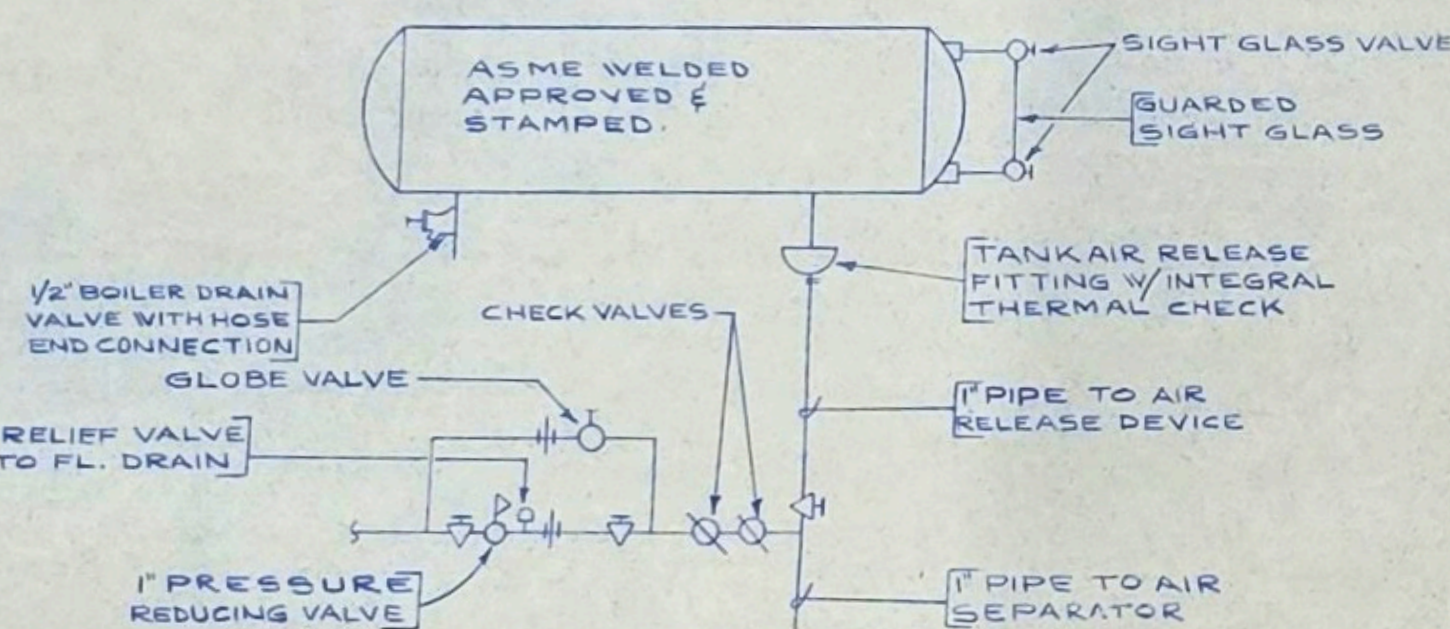




DETAIL OF EXPANSION TANK & COLD WATER MAKE-UP
NO SCALE

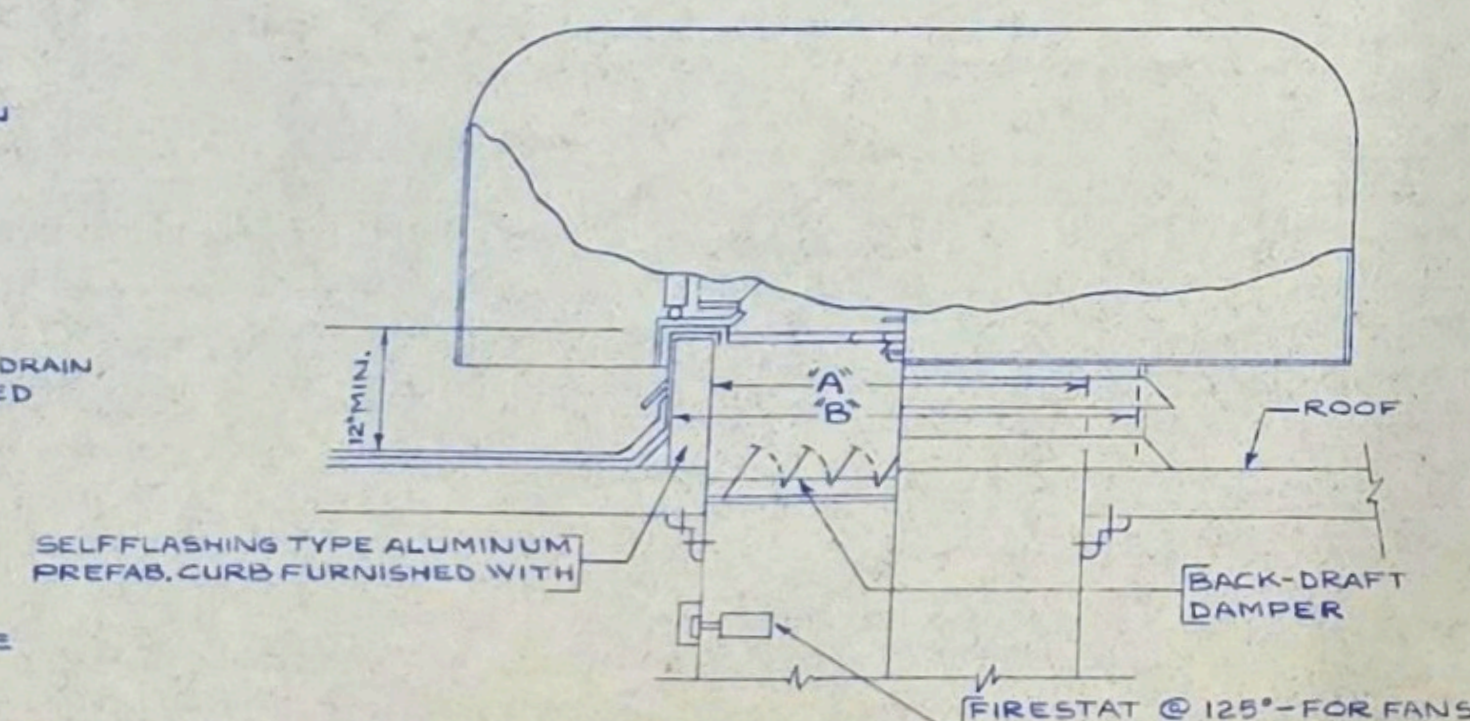

ROOF EXHAUST FANS
NO SCALE

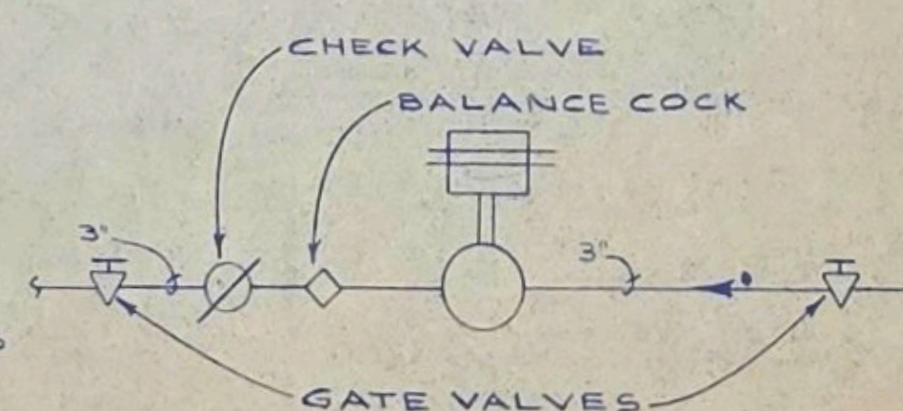


DOMESTIC HOT WATER HEATING PUMP PIPING

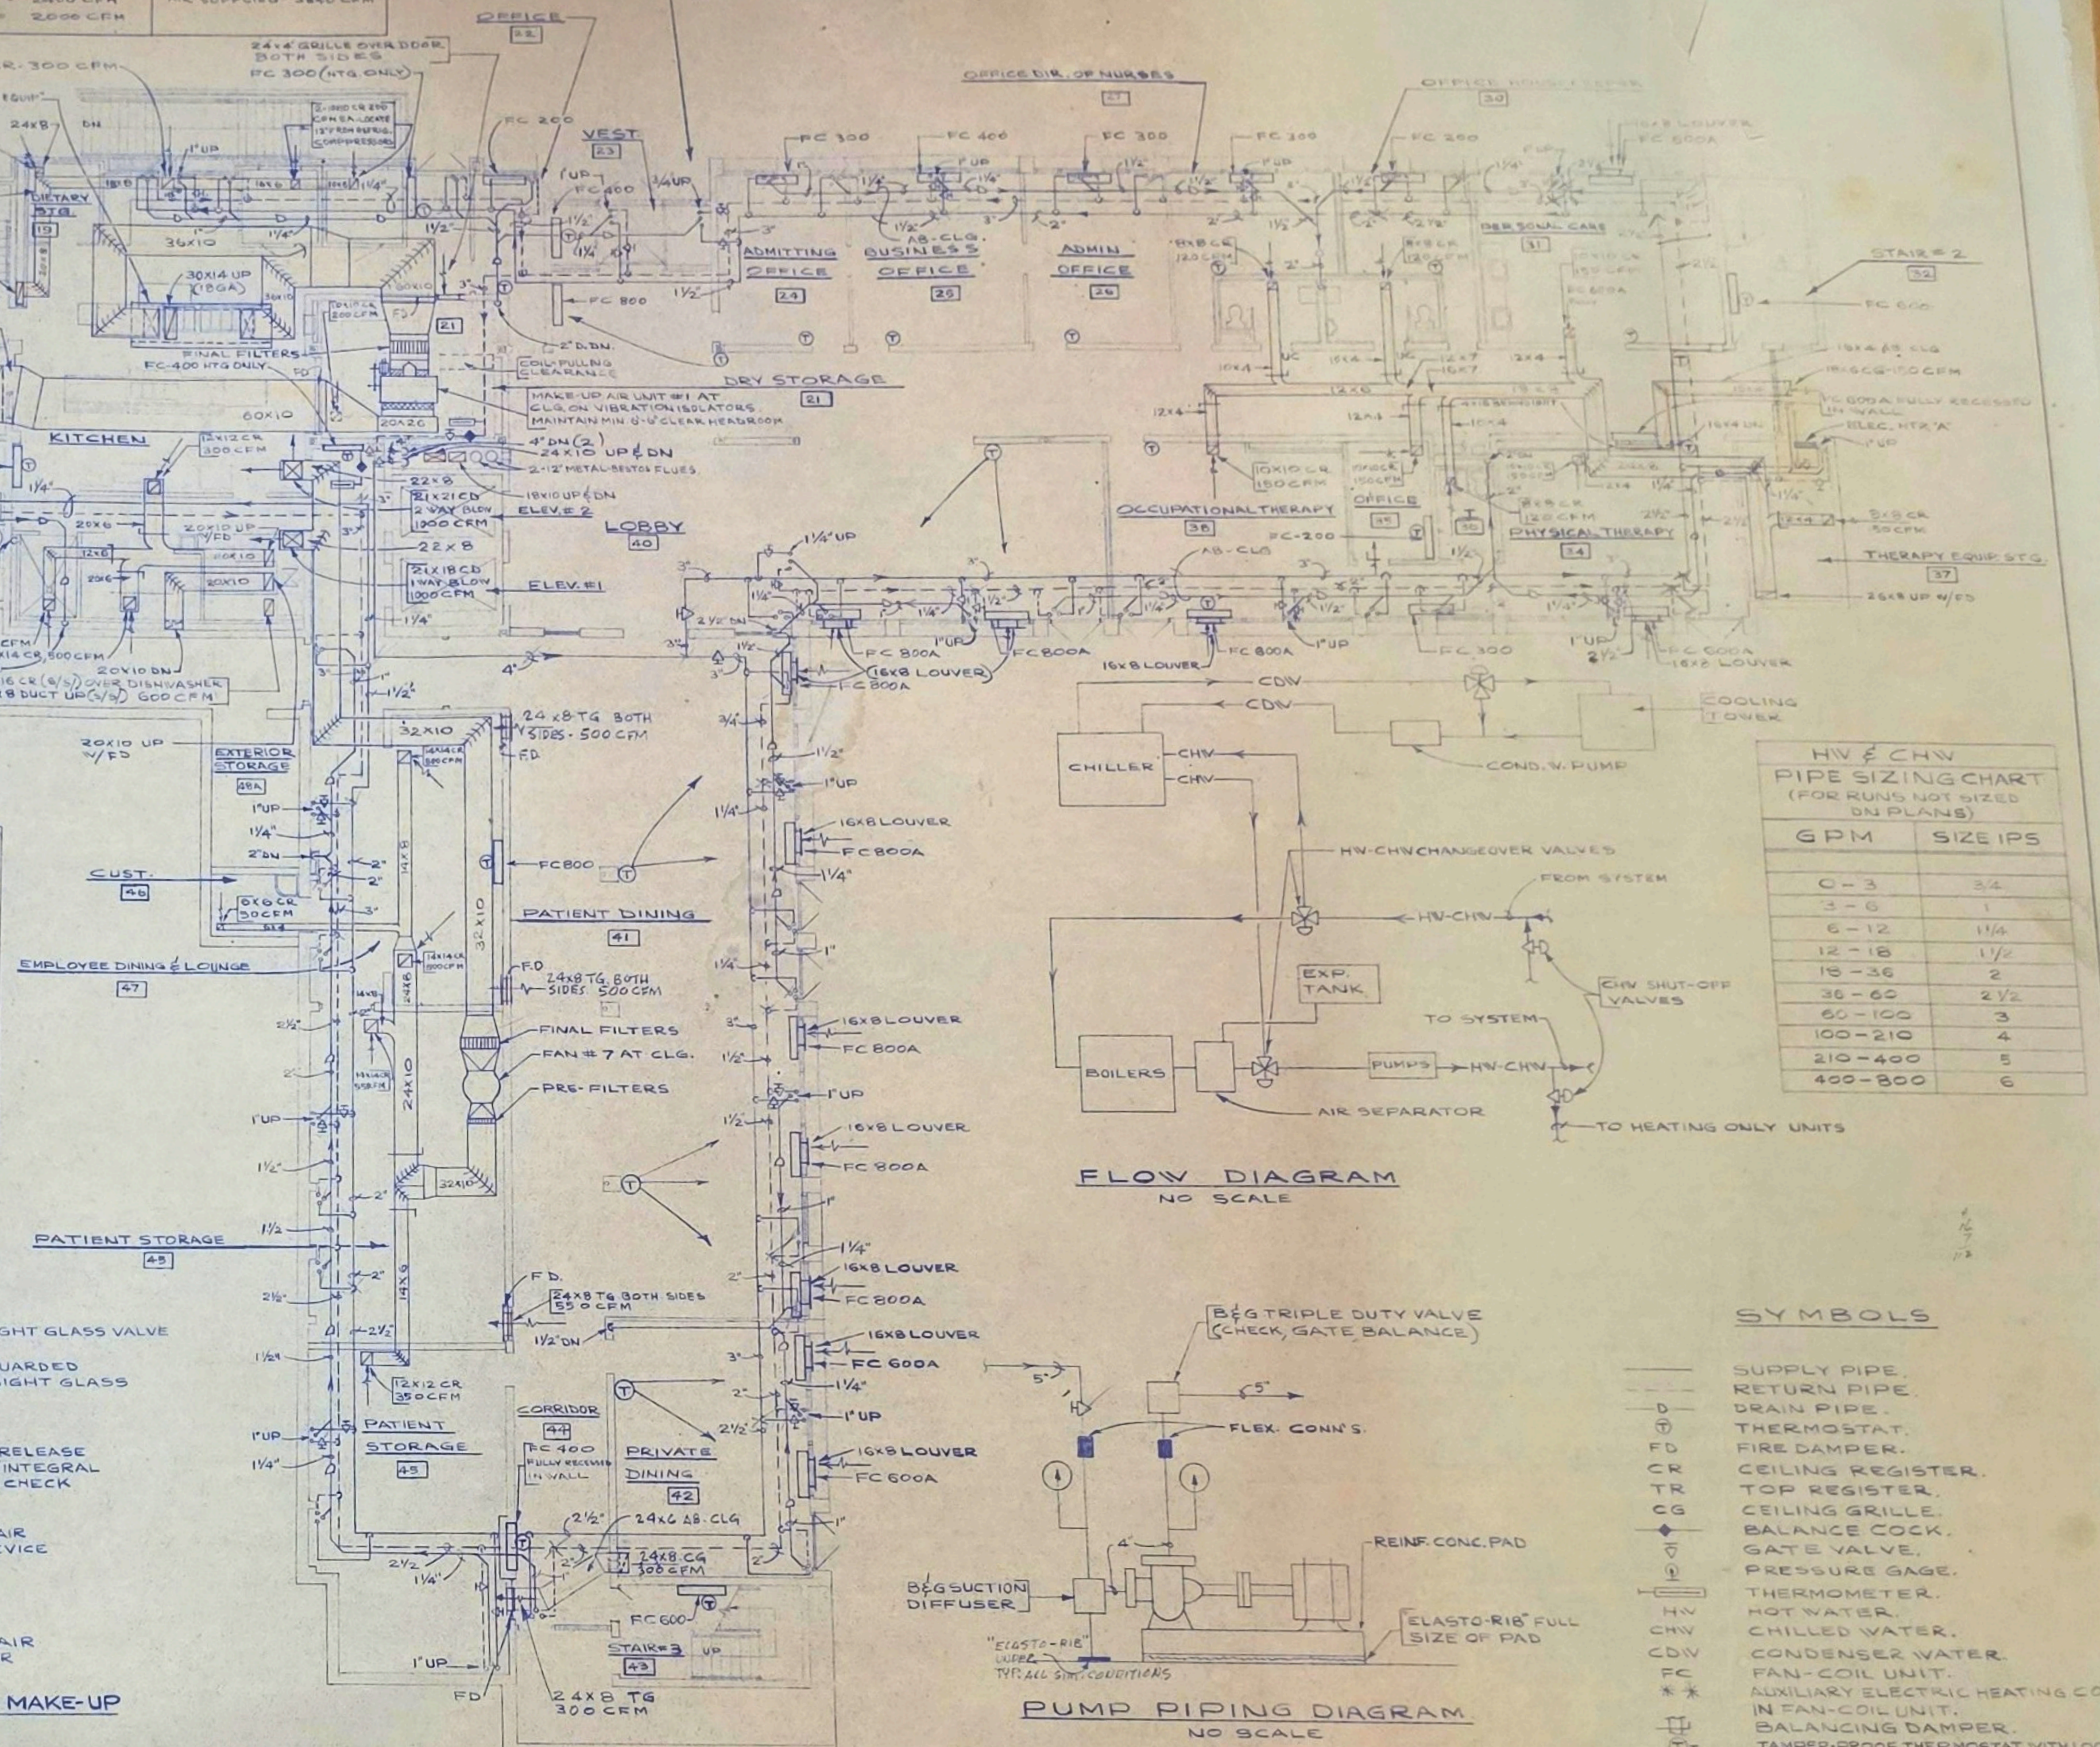  

FLOW DIAGRAM
NO SCALE

PUMP PIPING DIAGRAM
NO SCALE

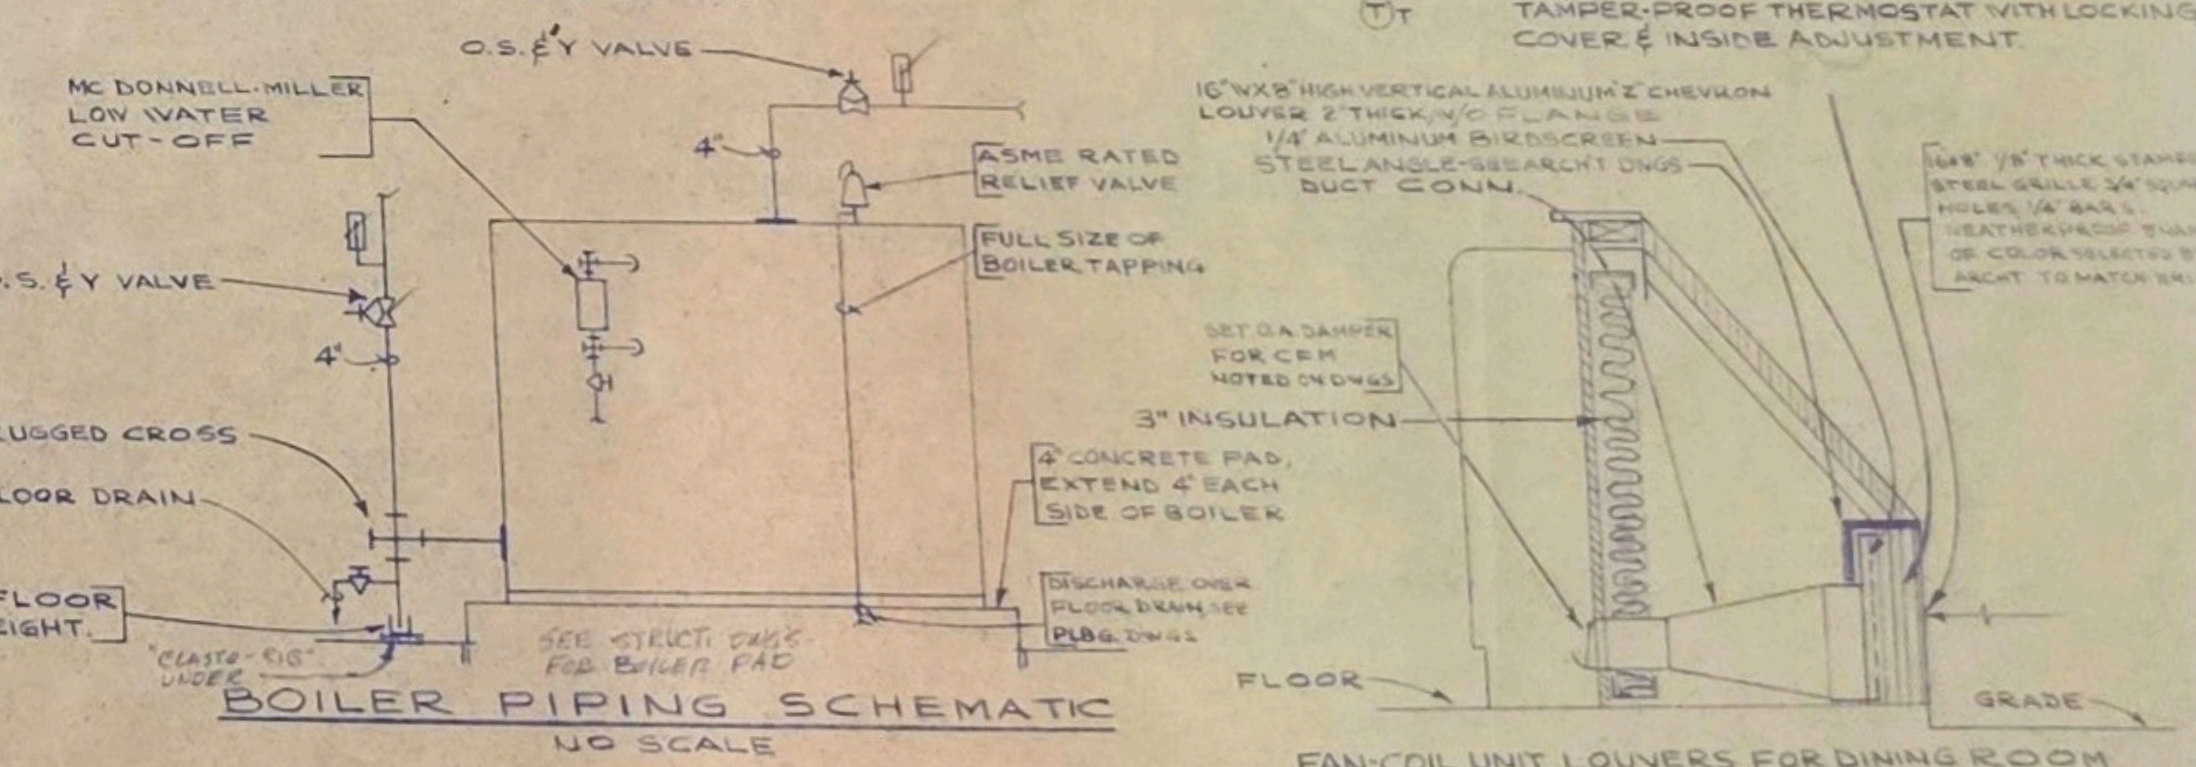

GROUND FLOOR PLAN ~ HVAC

DRAWINGS AND SPECIFICATIONS AS INSTRUMENTS OF SERVICE ARE THE PROPERTY OF THE ARCHITECT WHETHER THE WORK FOR WHICH THEY ARE MADE BE EXECUTED OR NOT, AND ARE NOT TO BE USED OR COPIED ON OTHER WORK EXCEPT BY WRITTEN AGREEMENT WITH THE ARCHITECT.

CONTRACTOR TO VERIFY ALL DIMENSIONS AND CONDITIONS IN THE FIELD BEFORE PROCEEDING WITH THE WORK.


ROCKVILLE NURSING HOME INC
301 ADCLARE ROAD ROCKVILLE, MARYLAND

eugene a delmar aia architect
850 Sligo Ave. Silver Spring Md. 20910 Tel. 585-8300

H2

HUD -

ROOF PLAN ~ ELECTRICAL

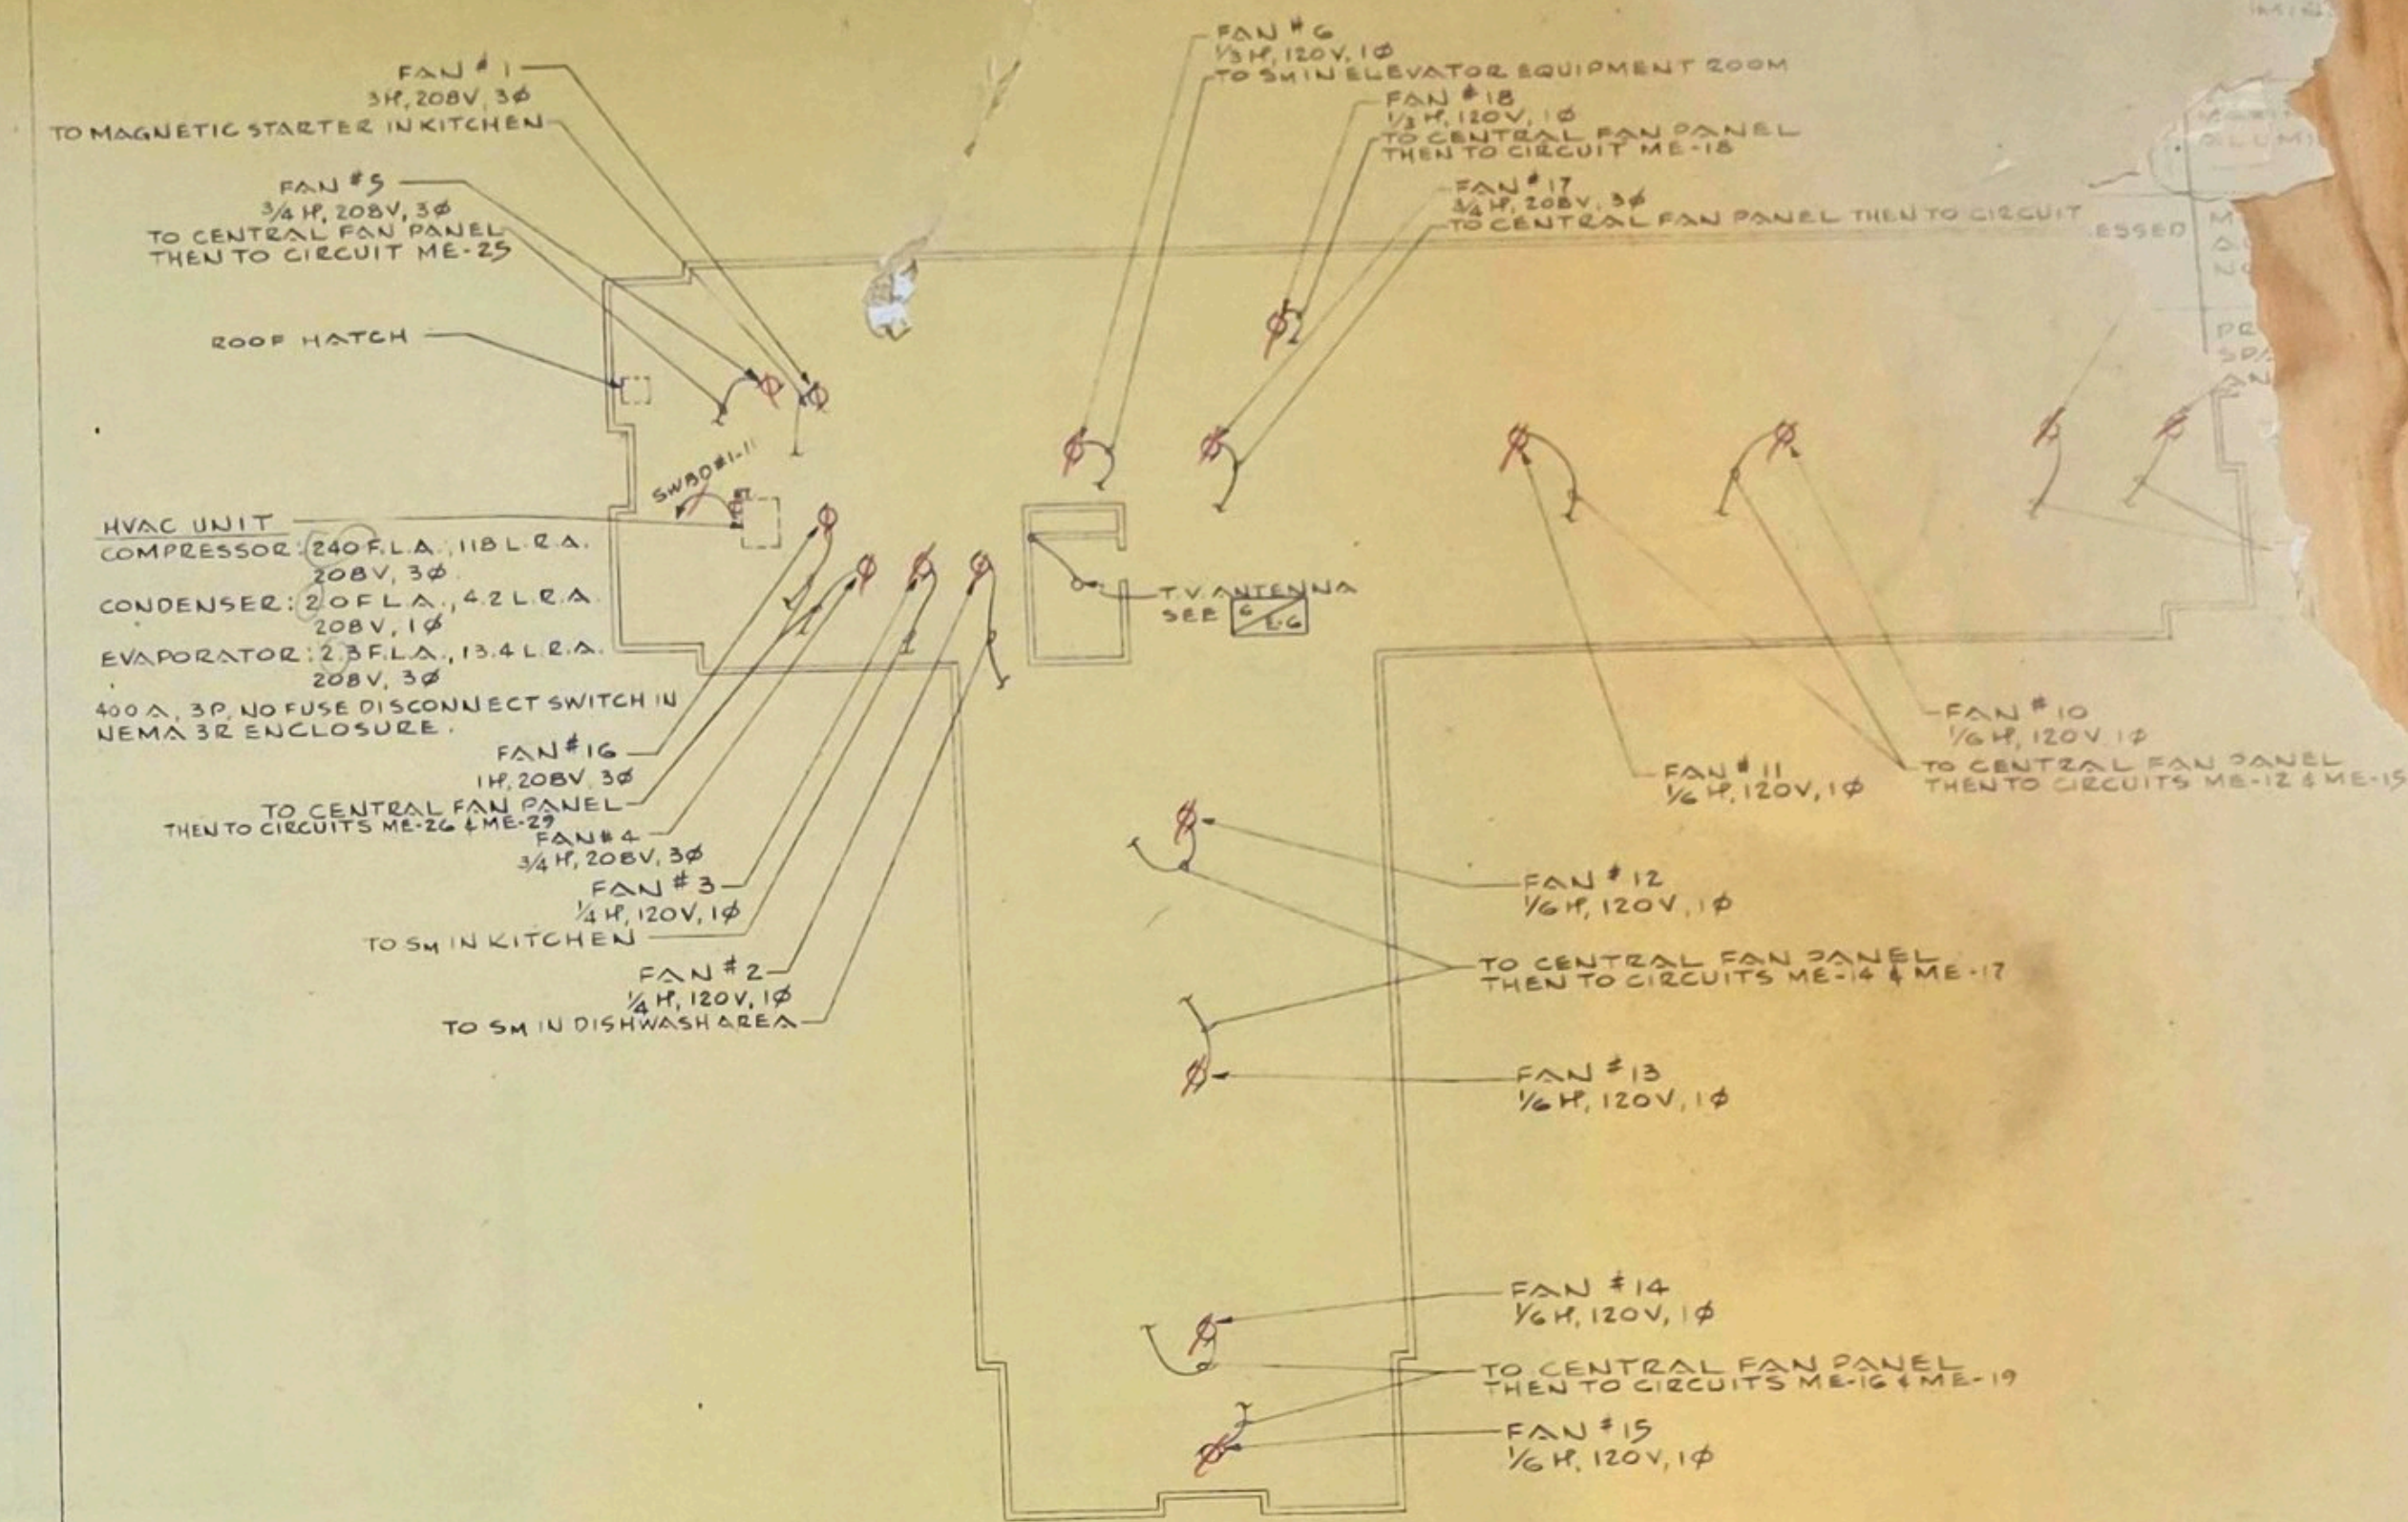

PANEL K						
CIRCUIT NUMBER	POLE	BRANCH CIRCUIT BREAKER FRAME	TRIP	CONDUCTOR SIZE	CONDUIT SIZE	SERVING
1, 3, 5, 7		100A FEA	20A	#12	3/4"	LIGHTS
2, 4						COOLER, FREEZER
6, 8						RECEPTACLES
9						ICE CREAM BOX
10						HOOD LIGHTS
11						MIXER
12						REFRIGERATOR
13						SLICER
14, 16						PLATE HEATERS
17	2		30A	#10		COFFEE URN
18	1		30A	#10		ICE MACHINE
19, 20	3		20A	#12		COOLER & FREEZER
21						TOASTER
22						FRYER (FUTURE)
23						HOT FOOD UNIT (SS)
24						FAN #1
25 (REV.)			60A	#6	1"	CONVECTION OVEN (1) (1)
26			100A	#1	1 1/4"	RANGE

PANEL K-1						
CIRCUIT	BRANCH CIRCUIT BREAKER	FRAME	TRIP	CONDUCTOR	CONDUIT	SERVING
TYPE "NAIB", 208/120 VOLTS, 3-PHASE, 4-WIRE, 225 A MAINS, LUGS ONLY						

NOTES

1. ✓ PROVIDE STANDARD PANEL TRIM AND BACK BOX. MOUNT ALL PANEL DOOR WITH LACED WIRE SLACK TO OPEN DOOR 30°.
2. ✓ MICARTA NAME PLATES (WHITE LETTERS ON BLACK) SCREWED COUNTER SUNK SCREWS.
3. ✓ FAN CONTROL DEVICES SHALL BE PROVIDED BY THE MECHANICAL AND INSTALLED AND ENERGIZED BY THE ELECTRICAL CONTRACTOR.
4. ✓ MANUAL STARTERS 24H-2L-11-PL-F PROVIDED, INSTALLED BY THE ELECTRICAL CONTRACTOR.
5. ✓ PROVIDE STANDARD PANELBOARD LOCK ASSEMBLY AND
6. ✓ PROVIDE PUNCHED OPENINGS FOR FUTURE DEVICES WITH COVERS PAINTED SAME COLOR AS PANEL TRIM.

REVISION: 1 REVISED KIT, EQUIP., LINEN & TRASH R.M. (SEE ARCH. DWG. 5H-A-1) 7/1/74


KITCHEN PLAN - ROOF PLAN & DETAILS - EL

ROCKVILLE NURSING HOME INC
301 ADCLARE ROAD ROCKVILLE, MARYLAND
eugene a delmar aia architect
850 Sligo Ave. Silver Spring Md. 20910 Tel. 585-8311

job no	72-1
scale	As shown
date	4-2-74
drawn by	H. C.
checked	V. J. T.

E 5

SWITCHBOARD DATA

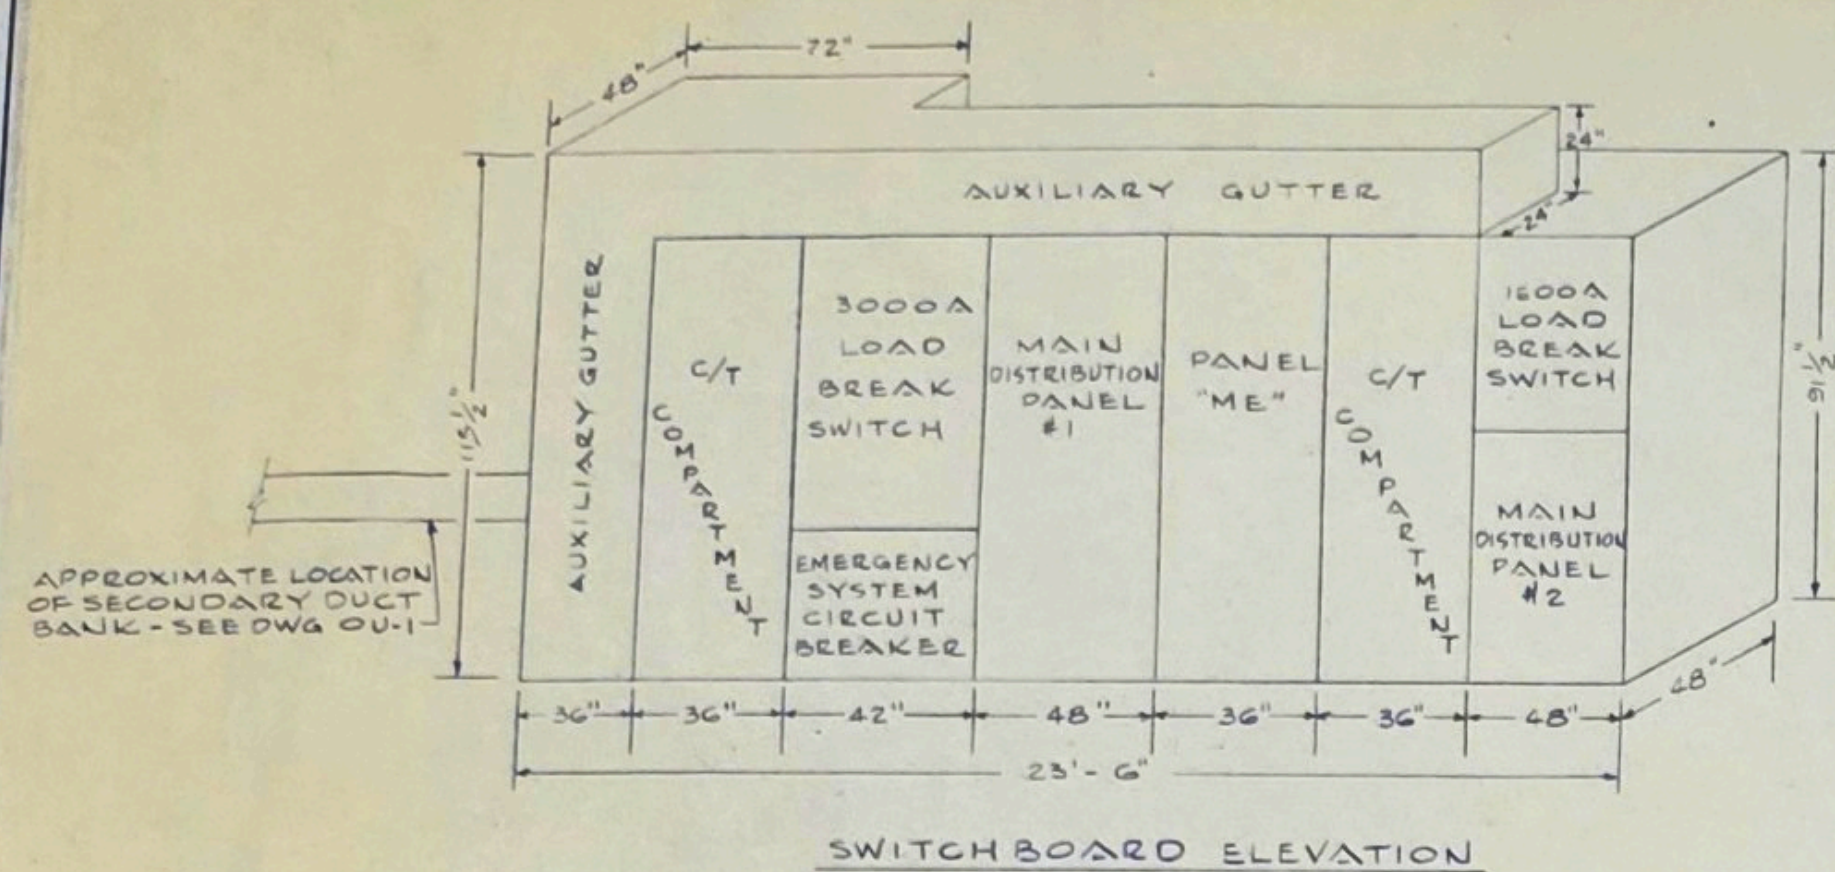


SWITCHBOARD #1 SCHEDULE
3000 AMP, 208/120 VOLTS, 3 PHASE, 4 WIRE
ALL BUS AND APPURTENANCES SHALL BE COPPER. SPACES SHALL HAVE ALL COMPONENTS TO RECEIVE FUTURE BREAKER WITHOUT DRILLING BUS, ETC.

NUMBER	POLE	FRAME	TRIP	SIZE	CONDUIT	SERVING
SECTION #1						
C/T SECTION BUILT-IN SWITCHBOARD SHALL CONFORM TO UTILITY CO. SPECIFICATIONS						
SECTION #2						
LOAD BREAK SWITCH 3000A, 3P+5N, UL APPROVED - 3000A "HCL" FUSES						
3	400A	MA	500A	300MCM	3"	PANEL "EM" 1
3	225A	KA	200A	300MCM	2"	PANEL "EM" 2
SECTION #3 - MOP #1						
1	3	225A	KH	100A	1"	DIMMER PANEL
2				100A	1"	PANEL "OL"
3				125A	2"	PANEL B-1
4				175A	2"	PANEL B-2
5				175A	2"	PANEL A-1
6						PANEL A-2
7						PANEL A-3
8				200A	2 1/2"	PANEL K-1
9				400A	300MCM	PANEL K
10						PANEL ME
11				350A		HVAC 200F UNIT
12				225A	125A	CONDENSER PUMP
13				600A	450A	CHILLER
14				225A	KA	SPACE
15, 16				225A	KH	SPACE
17				400A	LA	SPACE

SWITCHBOARD #2 SCHEDULE
1600 AMP, 208/120 VOLTS, 3 PHASE, 4 WIRE
ALL BUS AND APPURTENANCES SHALL BE COPPER. SPACES SHALL HAVE ALL COMPONENTS TO RECEIVE FUTURE BREAKER WITHOUT DRILLING BUS, ETC.

NUMBER	POLE	FRAME	TRIP	SIZE	CONDUIT	SERVING
SECTION #1						
C/T SECTION BUILT-IN SWITCHBOARD SHALL CONFORM TO UTILITY CO. SPECIFICATIONS						
SECTION #2						
LOAD BREAK SWITCH 1600A, 3P+5N, UL APPROVED - 1600A "HCL" FUSES						
1	3	225A	KH	125A	2"	PANEL D-1
2				150A		PANEL D-2
3				150A	2 1/2"	ELECTRIC COIL HEATER
4				200A	300MCM	PANEL C-1
5				200A	300MCM	PANEL C-2
6				200A	300MCM	PANEL C-3
7				400A	300A-500MCM	ELECTRIC COIL HEATER
8, 9				225A	KH	SPACE
10				400A	LA	SPACE

ELECTRICAL RISE & DIAGRAM

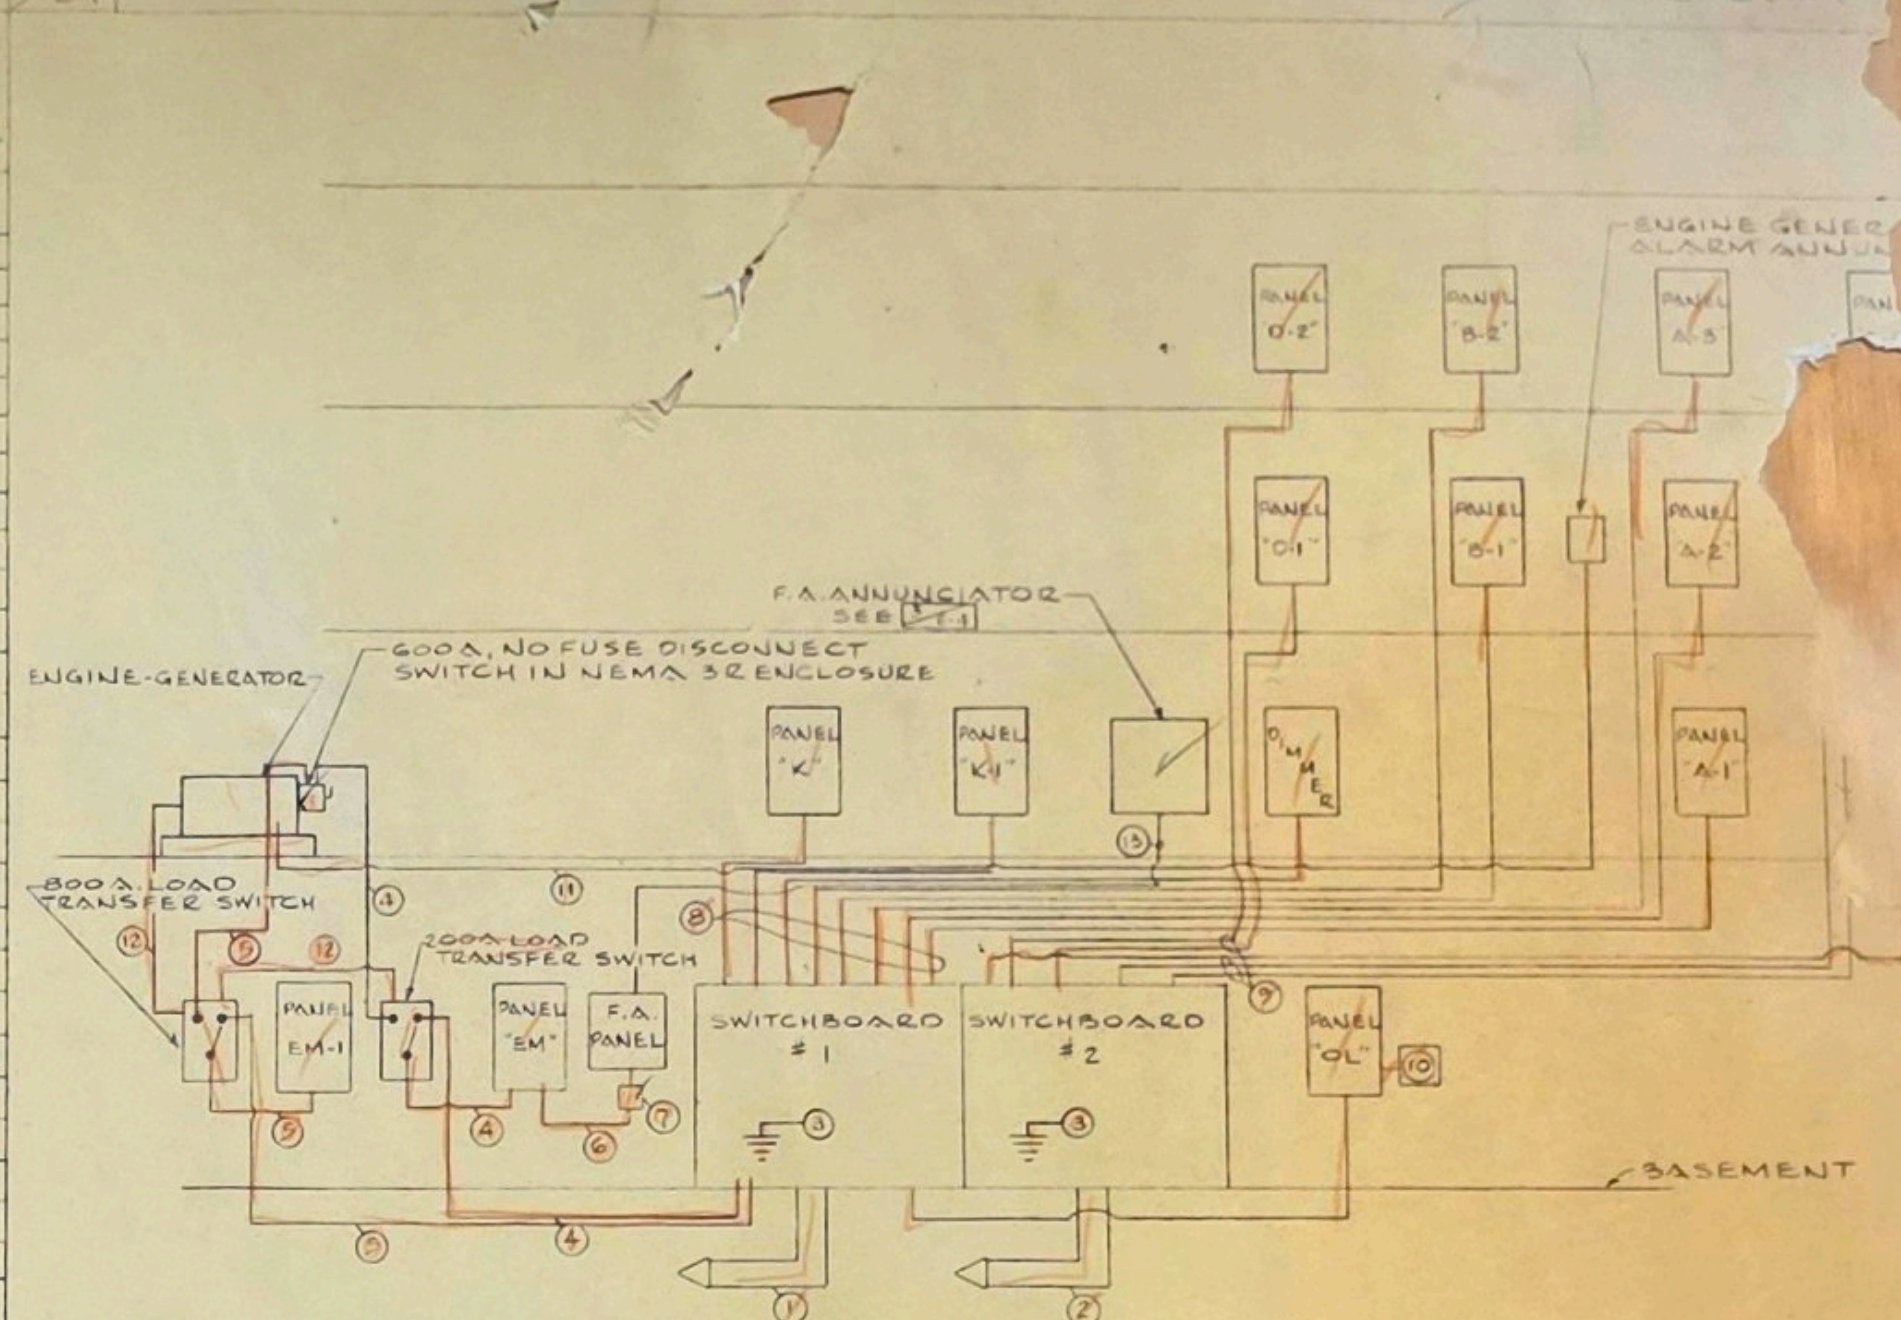


- ELECTRICAL RISER NOTES**
- TWELVE 4" KORDUCTS IN 3" CONCRETE ENVELOPE, TOP 3'-0" BELOW FINISHED GRADE. ALL TO ENTER AUXILIARY GUTTER. SEE SWITCHBOARD DETAIL AND DWG. 00-1
 - SIX 4" KORDUCTS IN 3" CONCRETE ENVELOPE, TOP 3'-0" BELOW FINISHED GRADE. ALL TO ENTER AUXILIARY GUTTER. SEE SWITCHBOARD DETAIL AND DWG. 00-1
 - ONE 3/4" INSULATED IN 1" CONDUIT, GROUND TO COLD WATER MAIN.
 - FOUR 3/4" IN 2" CONDUIT
 - TWO SETS OF FOUR 300MCM, EACH SET IN 3/4" CONDUIT
 - FOUR #12 IN 3/4" CONDUIT
 - FIRE ALARM PANEL FUSE RECOMMENDED BY FIRE AL.
 - FEEDERS SEE SWITCHBOARD
 - FEEDERS SEE SWITCHBOARD
 - TIME CLOCK TO 20K #12-120L-S-W SURFACE MOUNTED.
 - TEN #14 IN 1" CONDUIT
 - 1" CONDUIT WITH CONDUCTORS AS BY MANUFACTURER, FOR CONTROL
 - FOURTEEN #14 IN 1 1/4" CONDUIT

SWITCHBOARD SPECIFICATIONS
1600A AND 3000A, 208/120 VOLTS, 3 PHASE, 4 WIRE

- SWITCHBOARD NEMA CLASS 1 DEAD FRONT, TOTALLY ENCLOSED FRONT ACCESS ONLY. FREE STANDING RIGID STRUCTURE WITH NUMBER OF SECTIONS INDICATED. BOARD SHALL HOUSE INDICATED EQUIPMENT AND SHALL BE 91" HIGH INCLUDING BASE. SECTION FRAME ASSEMBLIES SHALL BE FORMED FROM STEEL CHANNELS AND ANGLES (12 GAGE MINIMUM). PROVIDE REMOVABLE COVERPLATES FRONT, SIDES, AND TOP. ENTIRE ASSEMBLY SHALL HAVE RUST INHIBITING PHOSPHATING TREATMENT. TWO COATS OF ASA 185 LIGHT GRAY ENAMEL INSIDE AND OUT.
- MAIN HORIZONTAL, VERTICAL AND NEUTRAL BUS SHALL BE FULL CAPACITY PLUS 25% GROUND BUS. PROVIDE RECTANGULAR SILVER OR TIN PLATED COPPER BARS WITH ALL JOINTS BOLTED. SWITCH AND CIRCUIT BREAKER INDIVIDUAL BUS TAPS SHALL BE SIZED FOR INDICATED RATINGS. LOAD BREAK SWITCHES SHALL HAVE COPPER COMPONENTS AND BUS CONNECTORS. BUS CAPACITY SHALL BE 1000 AMPS PER SQUARE INCH CROSS SECTION. CURRENT DENSITY WITH MAXIMUM RISE OF 50°C ABOVE 40°C AMBIENT AT RATED FULL LOAD CURRENT. ASSEMBLY TO BE RIGIDLY SUPPORTED, PROPERLY INSULATED AND BRACED FOR 75,000 AMPERE SHORT CIRCUIT CURRENT. BUS SPACING SHALL ALLOW ELECTRICAL CLEARANCE FOR APPLIED VOLTAGE BETWEEN PHASES AND PHASE TO GROUND. BUS SHALL NOT INTERFERE WITH FEEDER CABLES ENTERING OR LEAVING BOARD. ALL COMPONENTS SHALL BE COPPER.
- BOLTED PRESSURE LOAD BREAK SWITCHES. SWITCHES SHALL HAVE AN INTERRUPTING RATING OF 12 TIMES CONTINUOUS RATING AND HAVE AN OPERATING MECHANISM THAT SHALL PERMIT CLOSURE OF THE SWITCH ONLY AFTER THE OPENING MECHANISM HAS BEEN CHARGED. SWITCHES SHALL BE UL LABELED.
- PROVIDE SCHEMATIC ONE LINE DIAGRAM IN WHITE ON BLACK MICARTA FOR NEW SWITCHBOARD.
- SITE ASSEMBLY SHALL BE SUPERVISED BY MANUFACTURER. ALL COMPONENTS SHALL HAVE 1/2" X 6" MICARTA NAMEPLATES SCREWED TO ENCLOSURE. SWITCH BOARD SHALL FIT ALLOTTED SPACE WITH CODE CLEARANCES.
- SUBMIT 6 COPIES OF DIMENSIONED SHOP DRAWINGS INCLUDING ELEVATIONS, ONE LINE DIAGRAMS AND LIST OF COMPONENT CAPACITIES AND DESCRIPTIONS.
- MANUFACTURER: SQUARE "D", WESTINGHOUSE, G.E. OR I.T.E. WILL BE CONSIDERED.

NURSE'S CALL SYSTEM RISER DIAGRAM

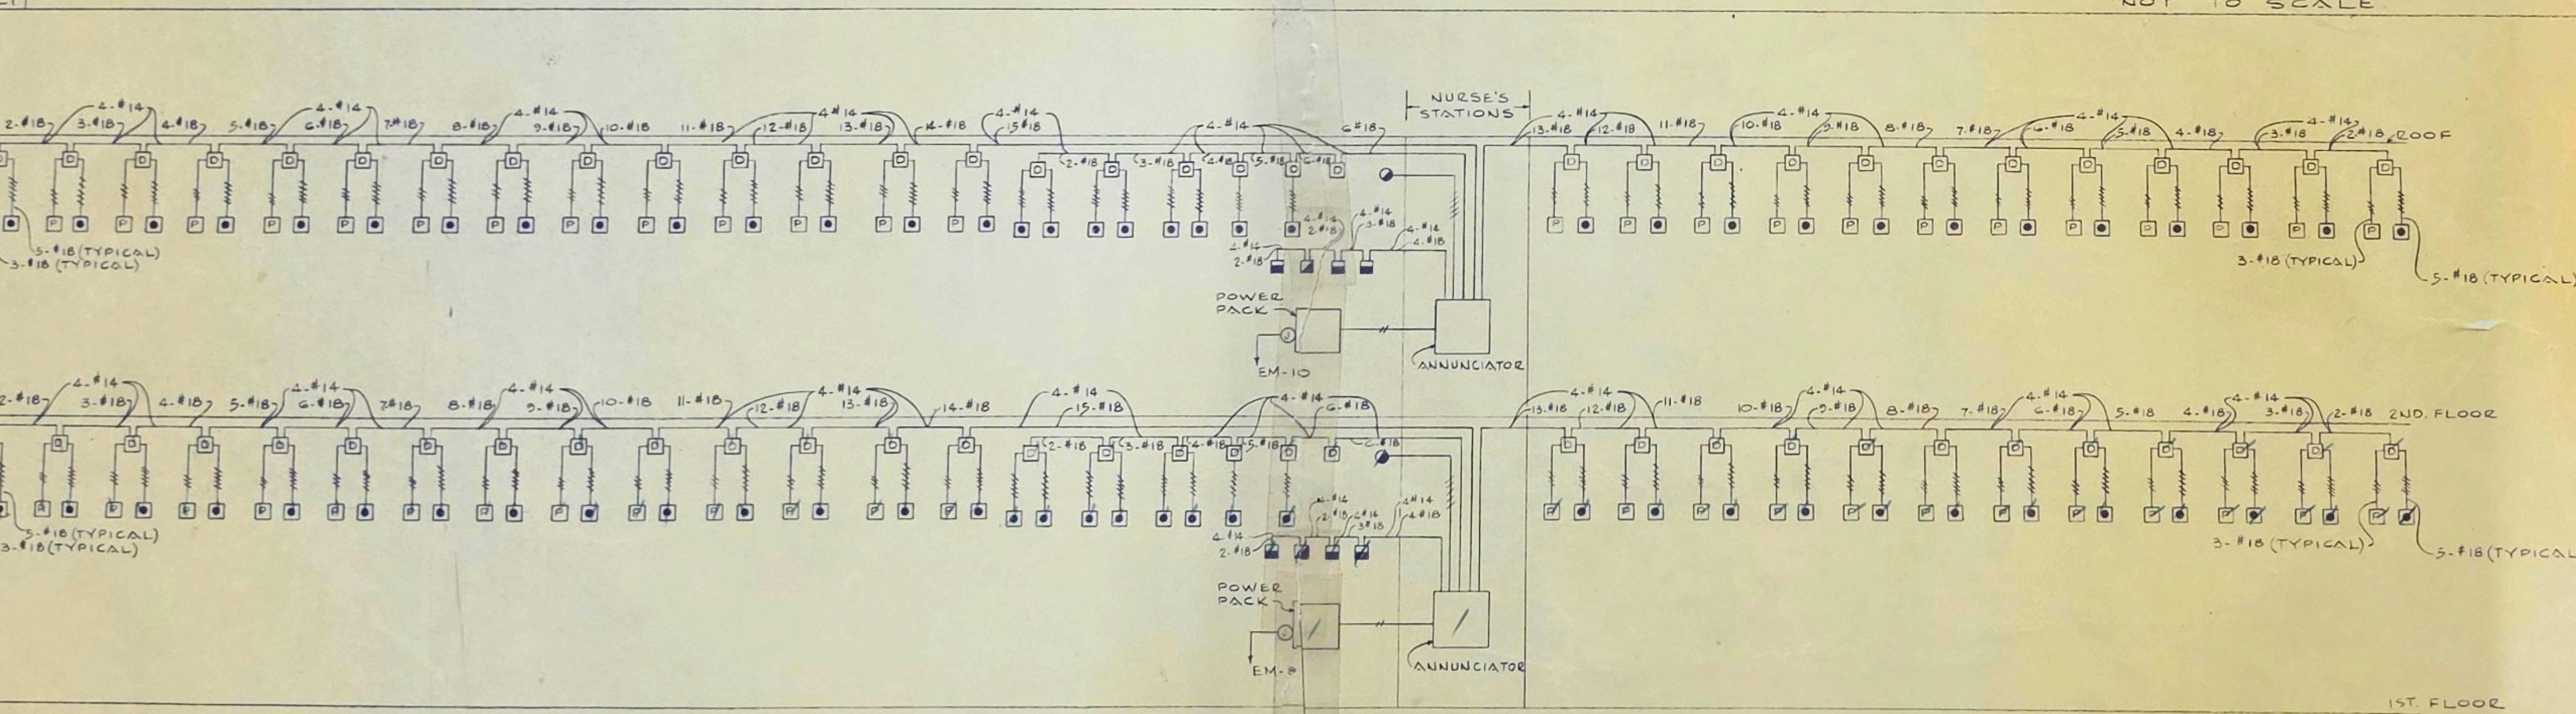

- NOTES:**
- HEIGHT OF ANNUNCIATOR TO BE AS DIRECTED
 - COLOR CODE SYSTEM AS RECOMMENDED BY EQUIPMENT MANUFACTURER.
 - SYSTEM TO BE RUN IN 3/4" EMT MINIMUM.

OPERATING INSTRUCTIONS

- OPERATING INSTRUCTIONS**
- PROVIDE 3 COMPLETE SETS, EACH SET IN 3-RING, HARD COVER NOT DELIVER TO ARCHITECT AT COMPLETION OF PROJECT. INCLUDE ONE MARKED WITH CONTRACT IDENTIFICATION OF INSTALLATION. ITEMS INCLUDING SCHEMATIC DIAGRAMS AND RELATI:
 - (1) ALL LAMINATES
 - (2) SWITCHBOARD AND PA
 - (3) FIRE ALARM AND SMOKE DETEC
 - (4) NURSE'S CALL SYS
 - (5) SOUND SYSTEM
 - (6) EMERGENCY ENGINE-GENER
 - (7) DOOR MONITOR
 - (8) TV SYSTEM COMPLETE WITH ANTENNA AND SCHEM
 - (9) SPECIAL ELECTRICAL EQUIPMENT AND SYSTEMS INCLUDING DIMA
 - NOTEBOOK INDEX SHALL INCLUDE NAMES, ADDRESSES AND PHONE NUMBERS OF EACH LOCAL EQUIPMENT SUPPLIER AND LOCAL SERVICE DEPARTMENT.
 - DEMONSTRATIONS: EACH OF THE ABOVE SYSTEMS SHALL BE DEMONSTRATED TO THREE PERSONS OFFICIALLY DESIGNATED BY THE OWNER. ALL DEMONSTRATIONS SHALL BE MADE BY AN AUTHORIZED FACTORY REPRESENTATIVE OF THE PARTICULAR SYSTEM INVOLVED.

DETAILS - ELECTRICAL

COMM. NO. 72-1331
7910 WOODMONT AVE.

ROCKVILLE NURSING HOME INC
301 ADCLARE ROAD ROCKVILLE, MARYLAND

eugene a delmar aia architect
850 Silgo Ave. Silver Spring Md. 20910 Tel. 585-8300

job no. 72-1
scale 1/4" = 1'-0"
date 4-2-74
drawn by E.C.
checked V.J.T.

E7