


Sheet Notes


- ALL DUCTWORK SIZES INDICATED ARE INSIDE FREE AREA DIMENSIONS UNLESS OTHERWISE NOTED.
- ALL INDOOR AIR HANDLING EQUIPMENT SHALL BE PROVIDED WITH A WATER-LEVEL DETECTION DEVICE CONFORMING TO UL 508 SHALL BE PROVIDED THAT WILL SHUT OFF THE EQUIPMENT SERVED IN THE EVENT THAT THE PRIMARY DRAIN IS BLOCKED. THE DEVICE SHALL BE INSTALLED IN THE PRIMARY DRAIN LINE. THE OVERFLOW DRAIN LINE OR IN THE EQUIPMENT SUPPLIED DRAIN PAN, LOCATED AT A POINT HIGHER THAN THE PRIMARY DRAIN LINE CONNECTION AND BELOW THE OVERFLOW RIM OF SUCH PAN.
- ALL PLUMBING DRAIN DISCHARGES OUTSIDE THE BUILDING SHALL BE TERMINATED AT LEAST 18" ABOVE THE FINISHED GROUND, SO AS TO AVOID SNOW LINE.
- REFER TO MANUFACTURERS RECOMMENDATIONS FOR SIZES AND ADDITIONAL INFORMATION.
- ALL TRADES ARE TO BE INDEPENDENTLY SUPPORTED, PER ALL TRADE STANDARDS AND NFPA. NOTHING CAN TOUCH THE SPRINKLER PIPING OR SUPPORT HANGERS. SYSTEMS CANNOT BE SUPPORTED FROM OTHER PARTS OF A SYSTEM. EACH PIPE SHOULD BE SUPPORTED INDEPENDENTLY OF EACH OTHER.
- ROUTE EXHAUST, RELIEF, AND OUTSIDE AIR DUCTWORK IN ATTIC SPACE TO EXTERIOR. COLLECT TO SINGLE BRICK VENT WITH MULTIPLE DUCTS. REFER TO DRAWING NOTE.

Keynotes


NO.	DESCRIPTION
5.01	INSTALL BATHROOM EXHAUST AIR TO EXTERIOR WITH CAP, BACKDRAFT DAMPER AND SCREEN.
5.02	INSTALL DRYER EXHAUST AIR TO EXTERIOR WITH CAP. SEE NOTE 5.04.
5.03	DRYER EXHAUST BOX. MAKE FINAL CONNECTION TO DRYER. PROVIDE FANTECH DBF 110 DRYER BOOSTER FAN AND DRAIN PAN LIFT TRAP OR SIMILAR WHERE BOOSTER FAN IS NOTED ON PLANS.
5.04	INSTALL DRYER, BATHROOM EXHAUST, AND RANGE HOOD EXHAUST TO EXHAUST BOX, THEB-446-S, WITH SEPARATION FINS AND BACKDRAFT DAMPERS. USE TRIPLE FOR SINGLE UNIT OR 6 OUTLET BOX FOR MULTIPLE UNITS AT THE SAME GABLE END.
6.05	REFER TO DETAILS FOR ADDITIONAL INFORMATION.

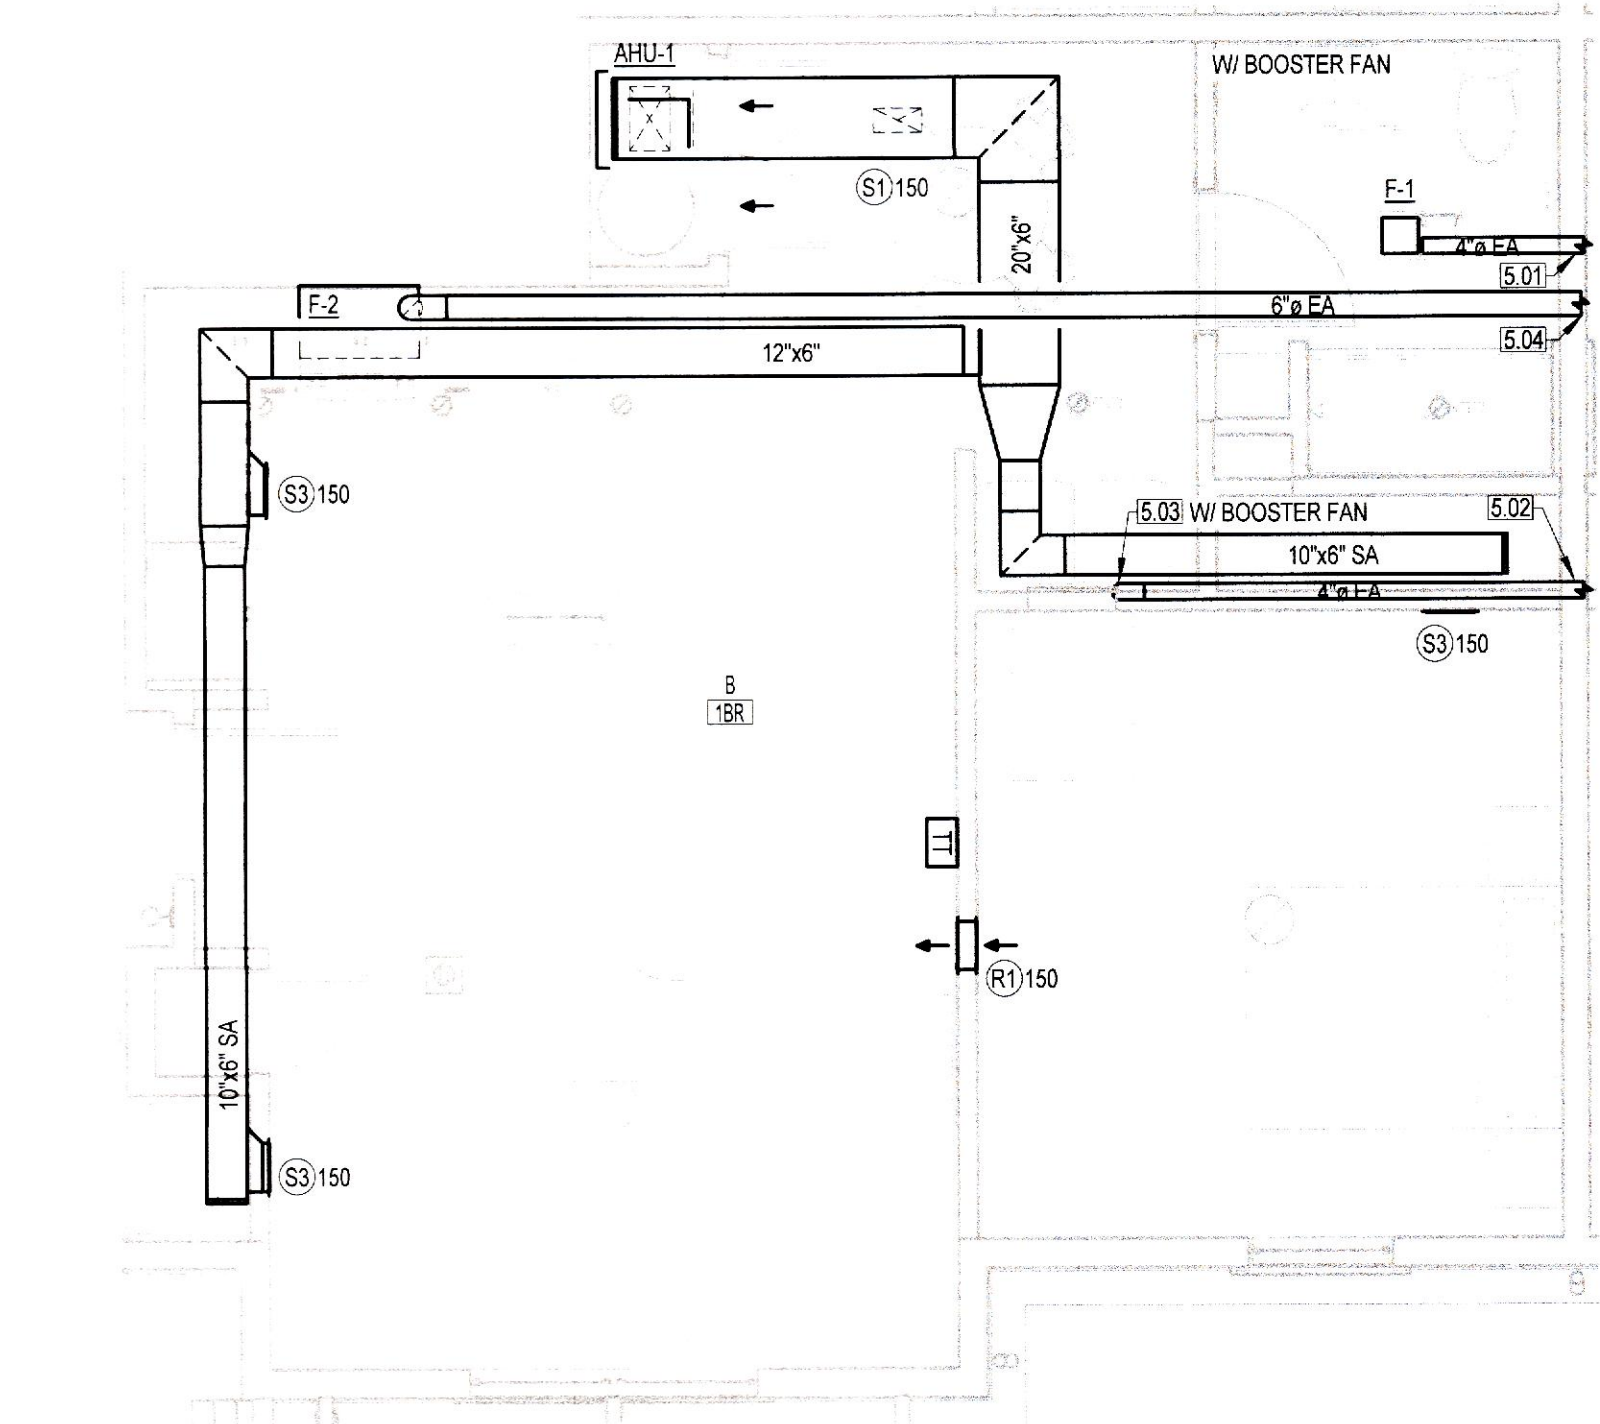


1 Floor Plan | Unit B | One Bedroom | Mechanical

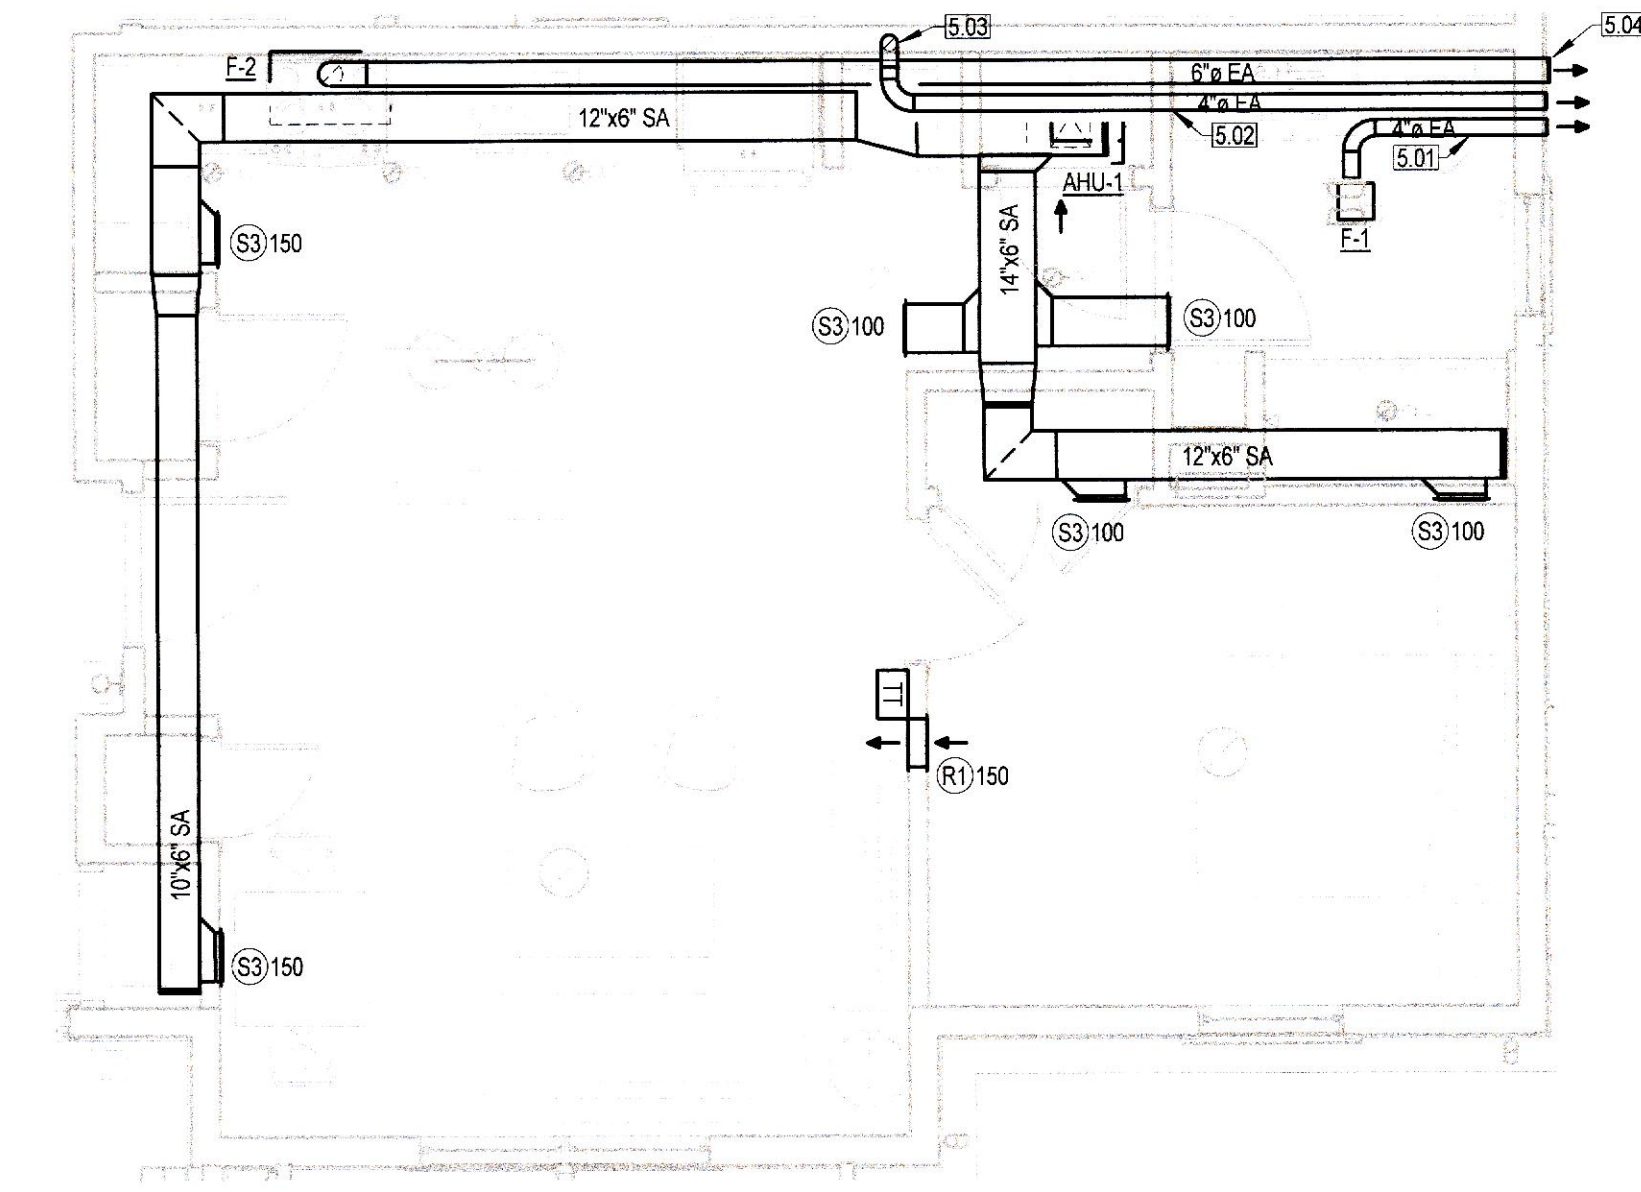

2 Floor Plan | Unit A | One Bedroom | 610 SF | Mechanical

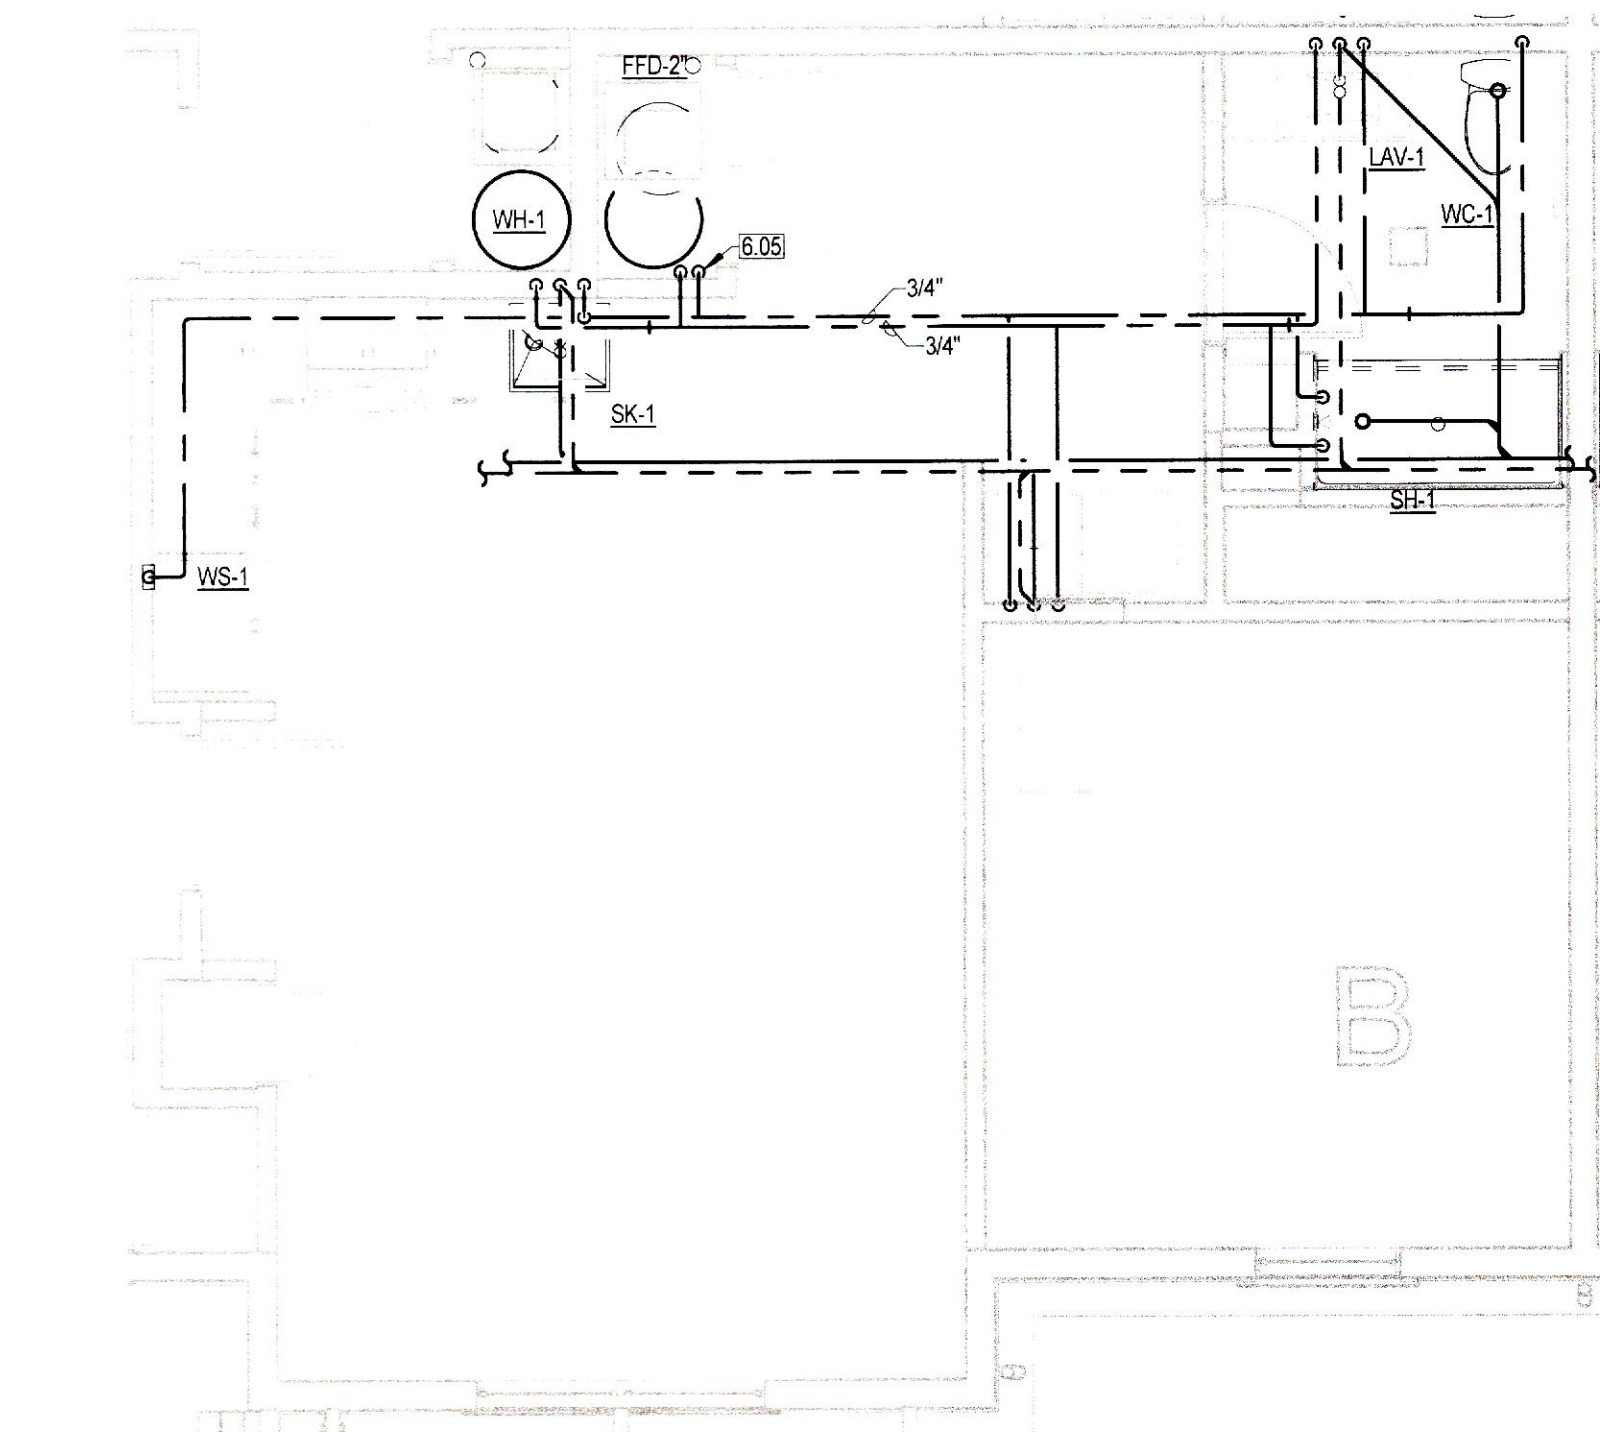

3 Floor Plan | Unit B | One Bedroom | Plumbing

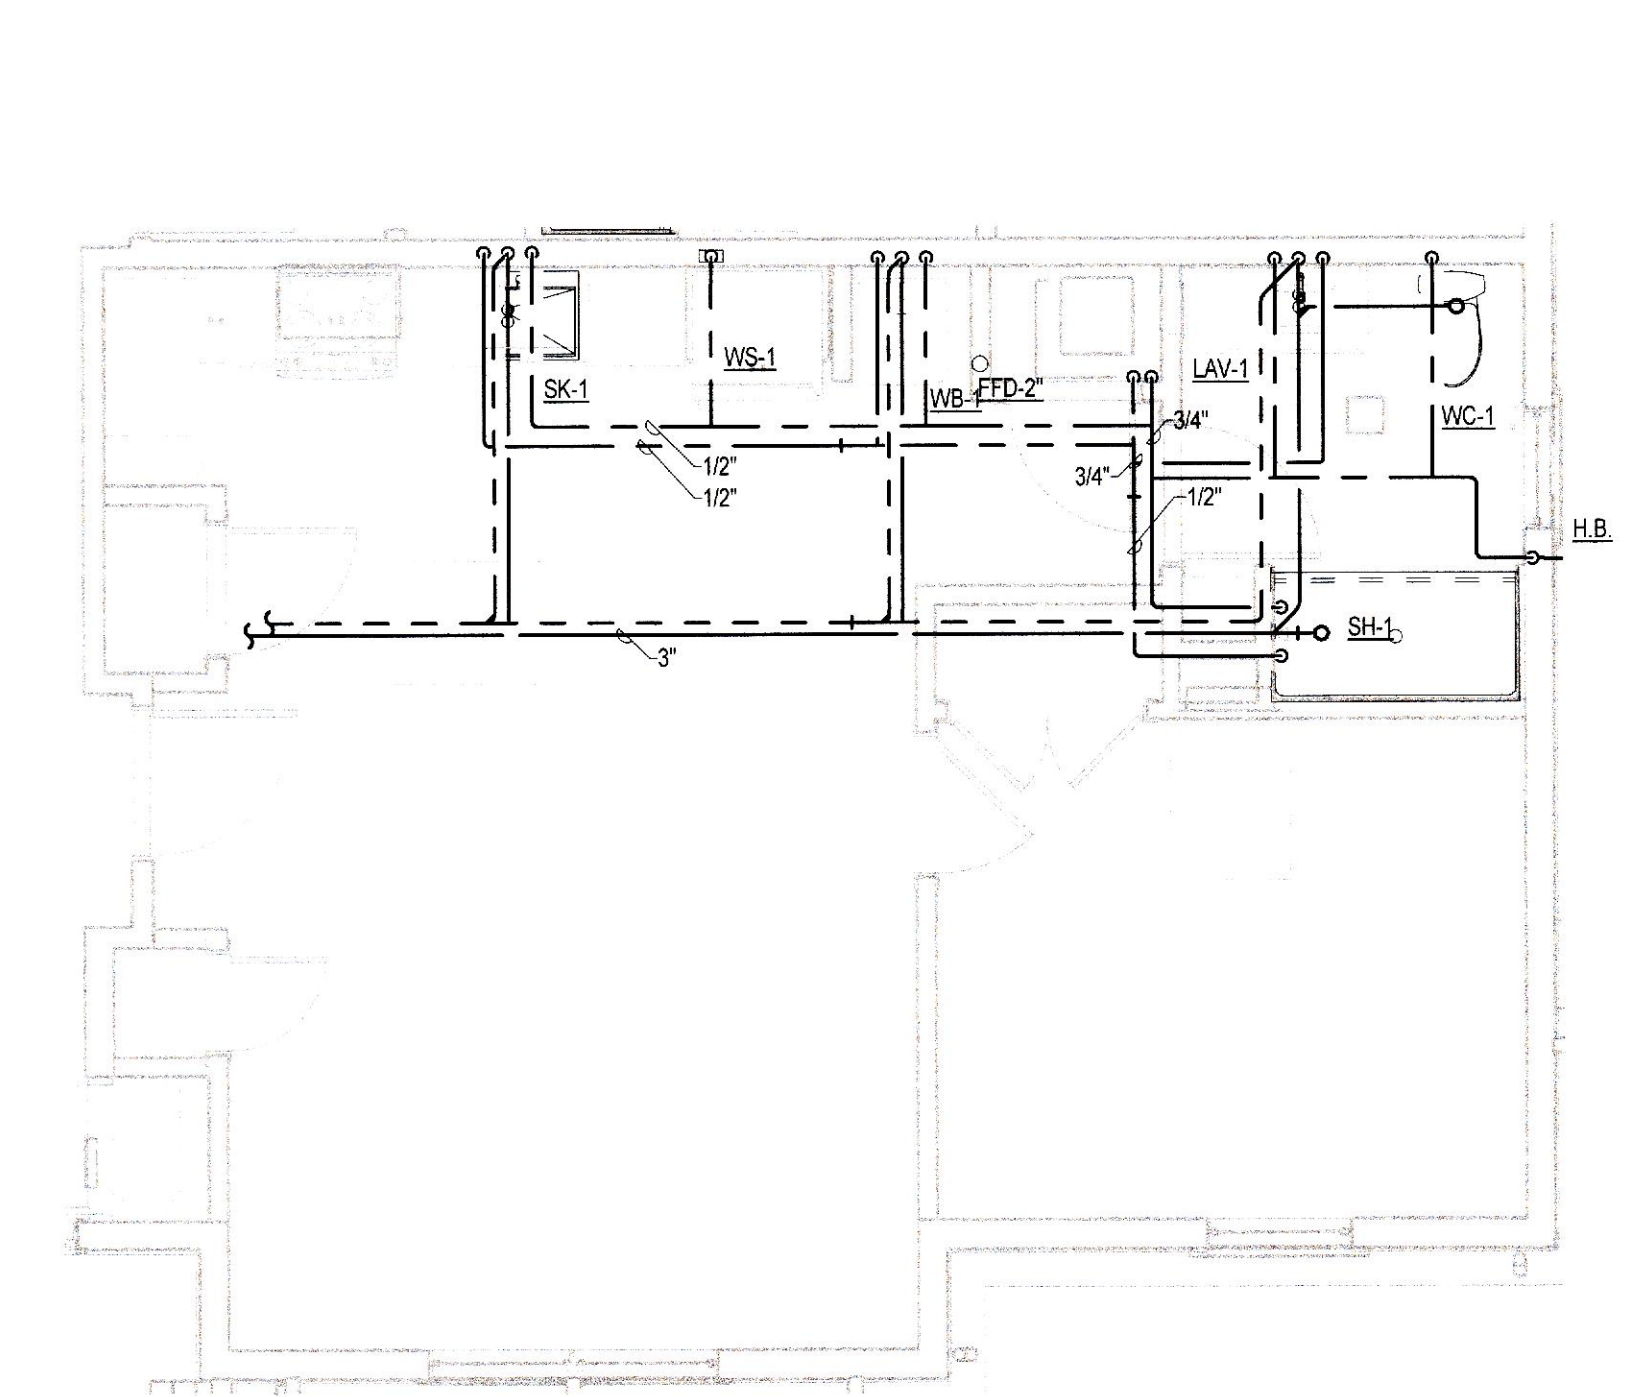

4 Floor Plan | Unit A | One Bedroom | 610 SF | Plumbing

PROJECT PROJ. NO.: 22-15

Millington Senior Village

Residential Buildings

172 Sassafraas Street
Millington, MD 21651

PRESENT OPEN COMPANY

PROJECT DIRECTORY

DEVELOPER
Home Partnership of Cecil County, Inc
626 TOWNE CENTER DRIVE, SUITE 102
JOPPA, MD 21085
TEL 410.679.3200

CIVIL ENGINEER
Atwell, LLC
4692 MILLENNIUM DRIVE, SUITE 305
BELCAMP, MD 21017
TEL 302.369.2900

ARCHITECT
Present Company
2209 MARYLAND AVE
BALTIMORE, MD 21218
TEL 410.696.3321

STRUCTURAL ENGINEER
Skarda and Associates
2439 N CHARLES STREET
BALTIMORE, MD 21218
TEL 410.366.9384


MEP ENGINEER
Bowley Jones
1107 BURKHARDT LANE
SEVERN, MARYLAND, 21144
TEL 410.777.9493

ENERGY CONSULTANT
Lorax Partnerships, LLC
808 ST. PAUL STREET
BALTIMORE, MD 21202
TEL 443.449.6319

GENERAL CONTRACTOR
Willow Construction
8649 COMMERCE DRIVE
EASTON, MD 21601
TEL 410.822.6000

© 2024 PRESENT COMPANY. ALL RIGHTS RESERVED.

PROFESSIONAL CERTIFICATION

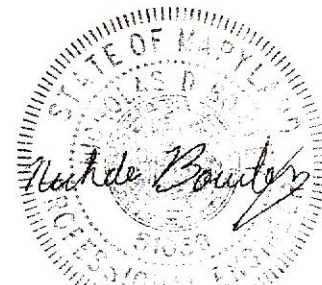

Professional Certification: I hereby certify that these documents were prepared or approved by me, and that I am a duly licensed professional engineer under the laws of the State of Maryland. License No. 51059, Expiration Date: 06-01-2027.

REVISIONS

DATE NO. ISSU

SUBMISSION

100% Construction Documents
PERMIT SET REISSUE
June 22, 2026

DRAWING NAME / NO. SCALE: 1/4" = 1'-0"

ENLARGED VIEWS - MECHANICAL

M401

MODEL HOSE BIBBS