




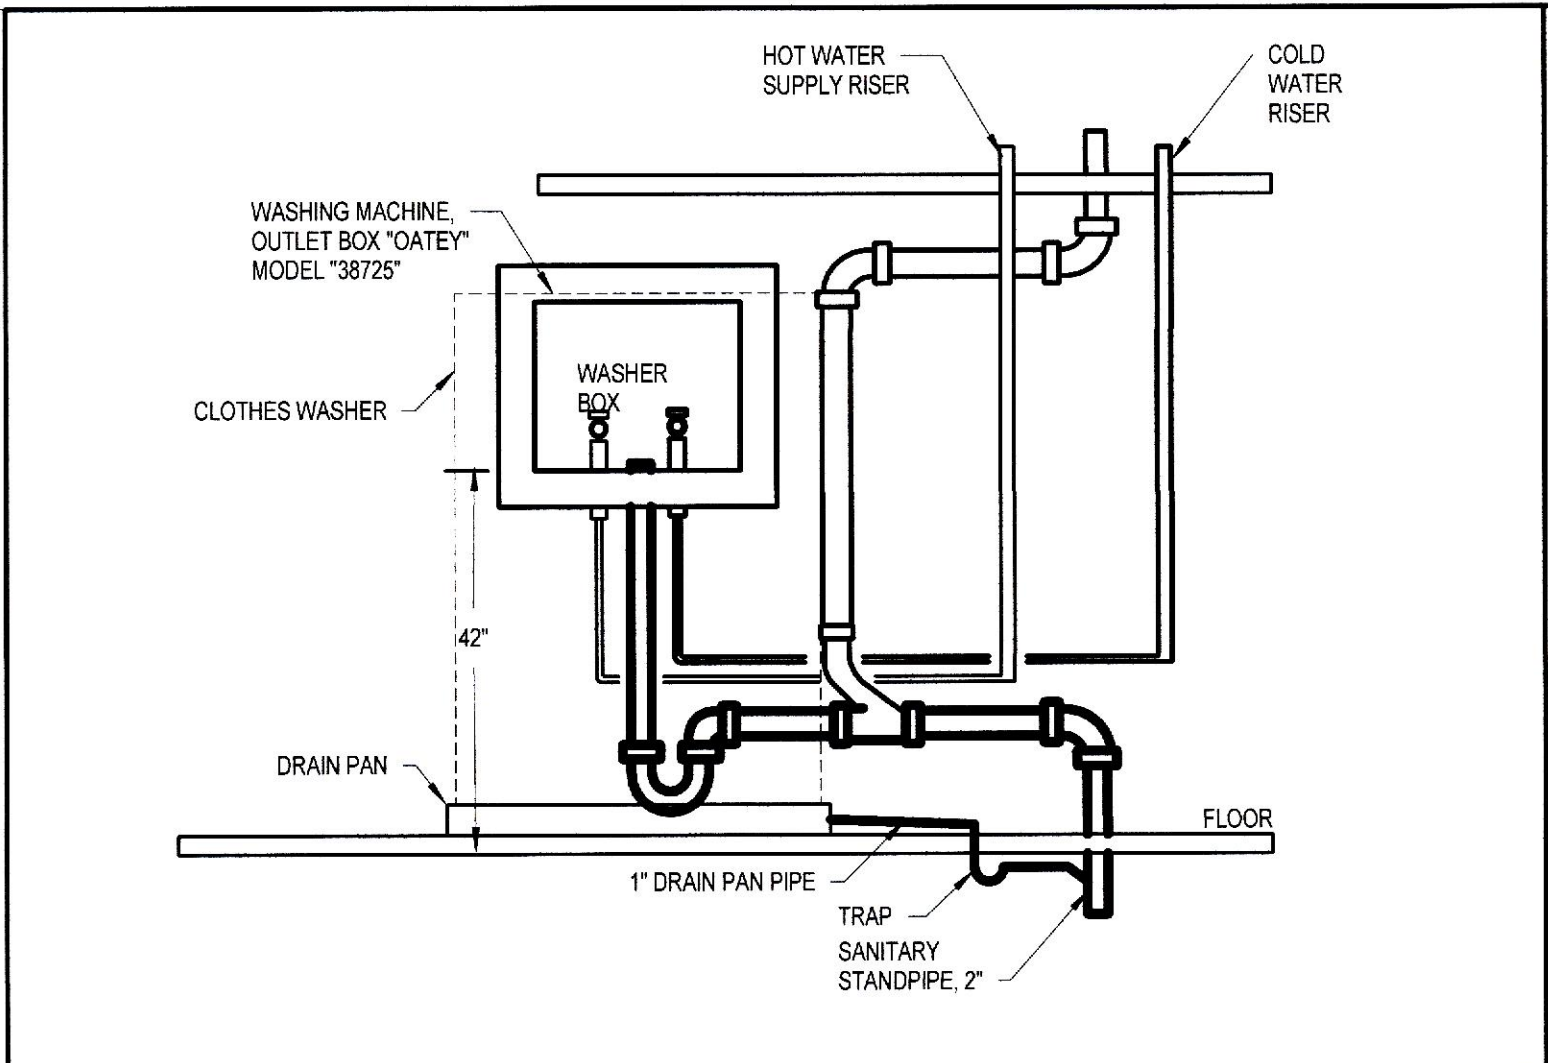


WASHING MACHINE OUTLET BOX DETAIL

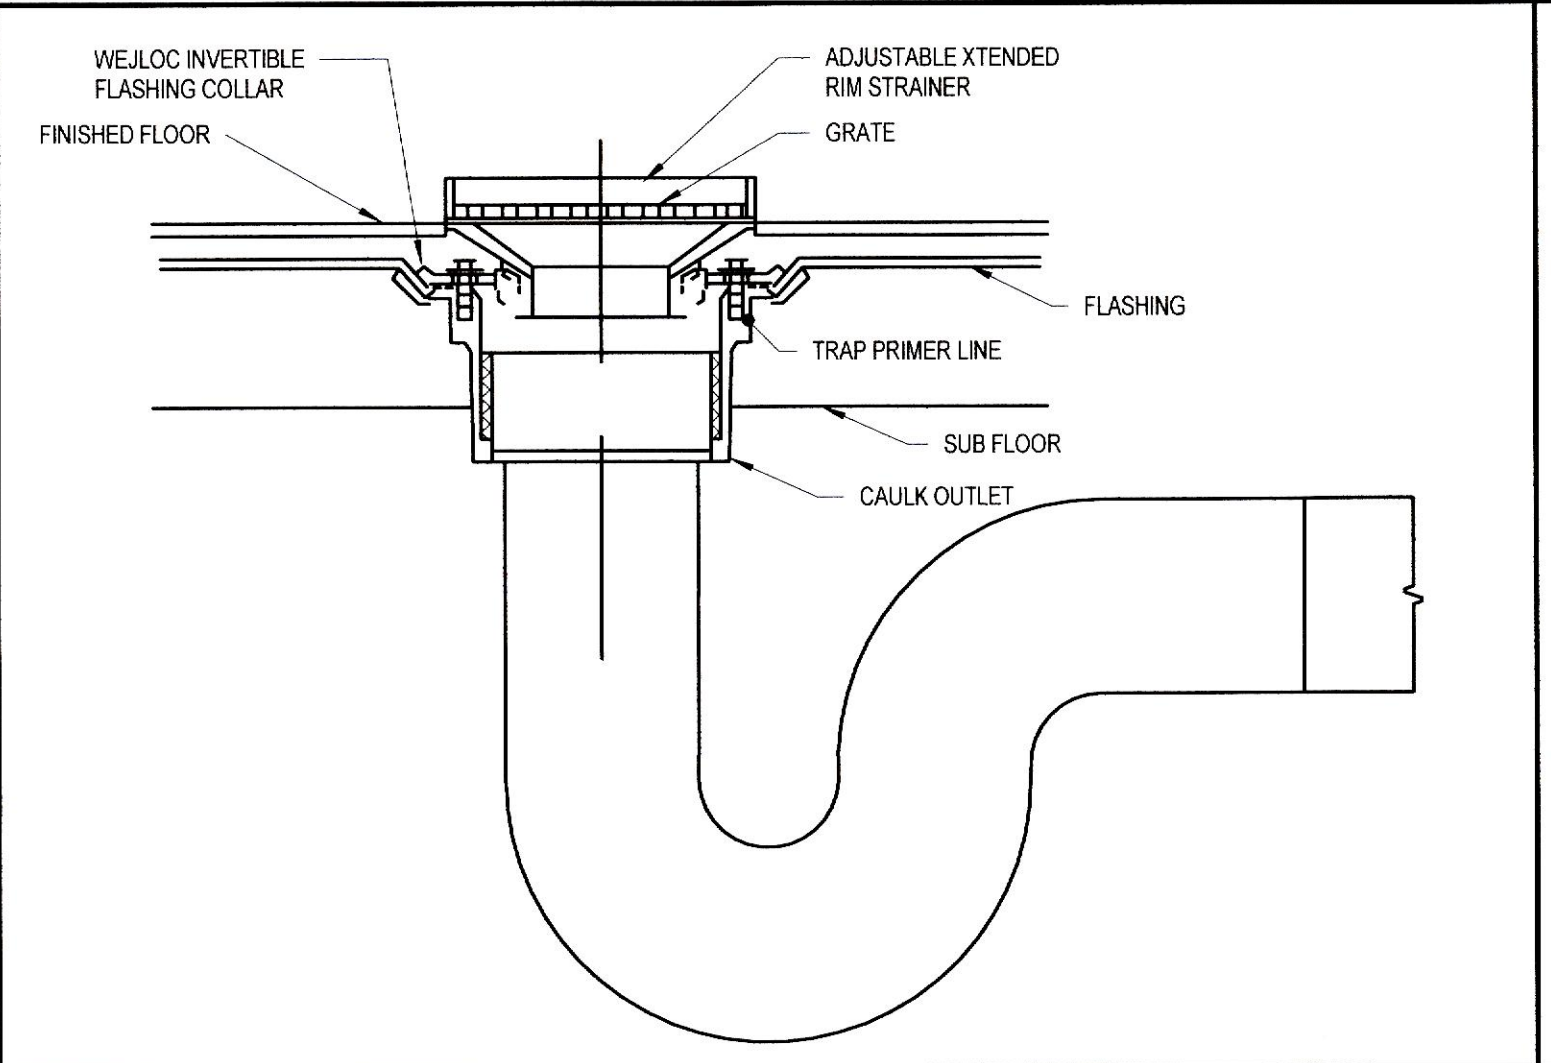


MECHANICAL ROOM FLOOR DRAIN DETAIL

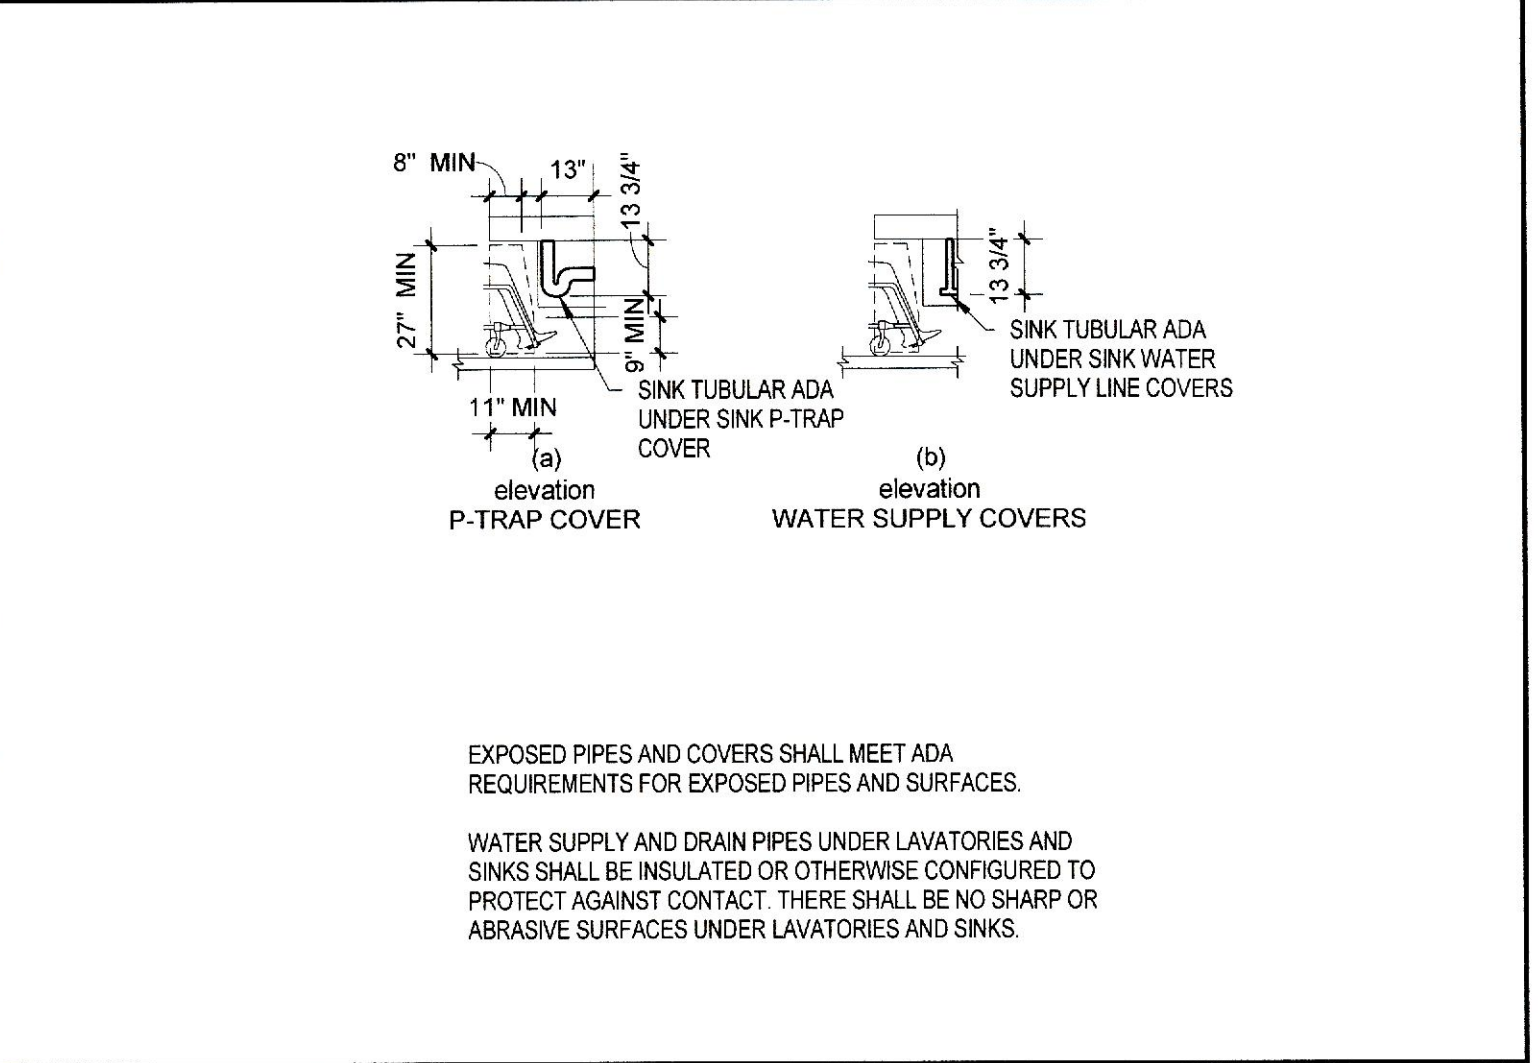


ADA PIPE PROTECTION DETAIL

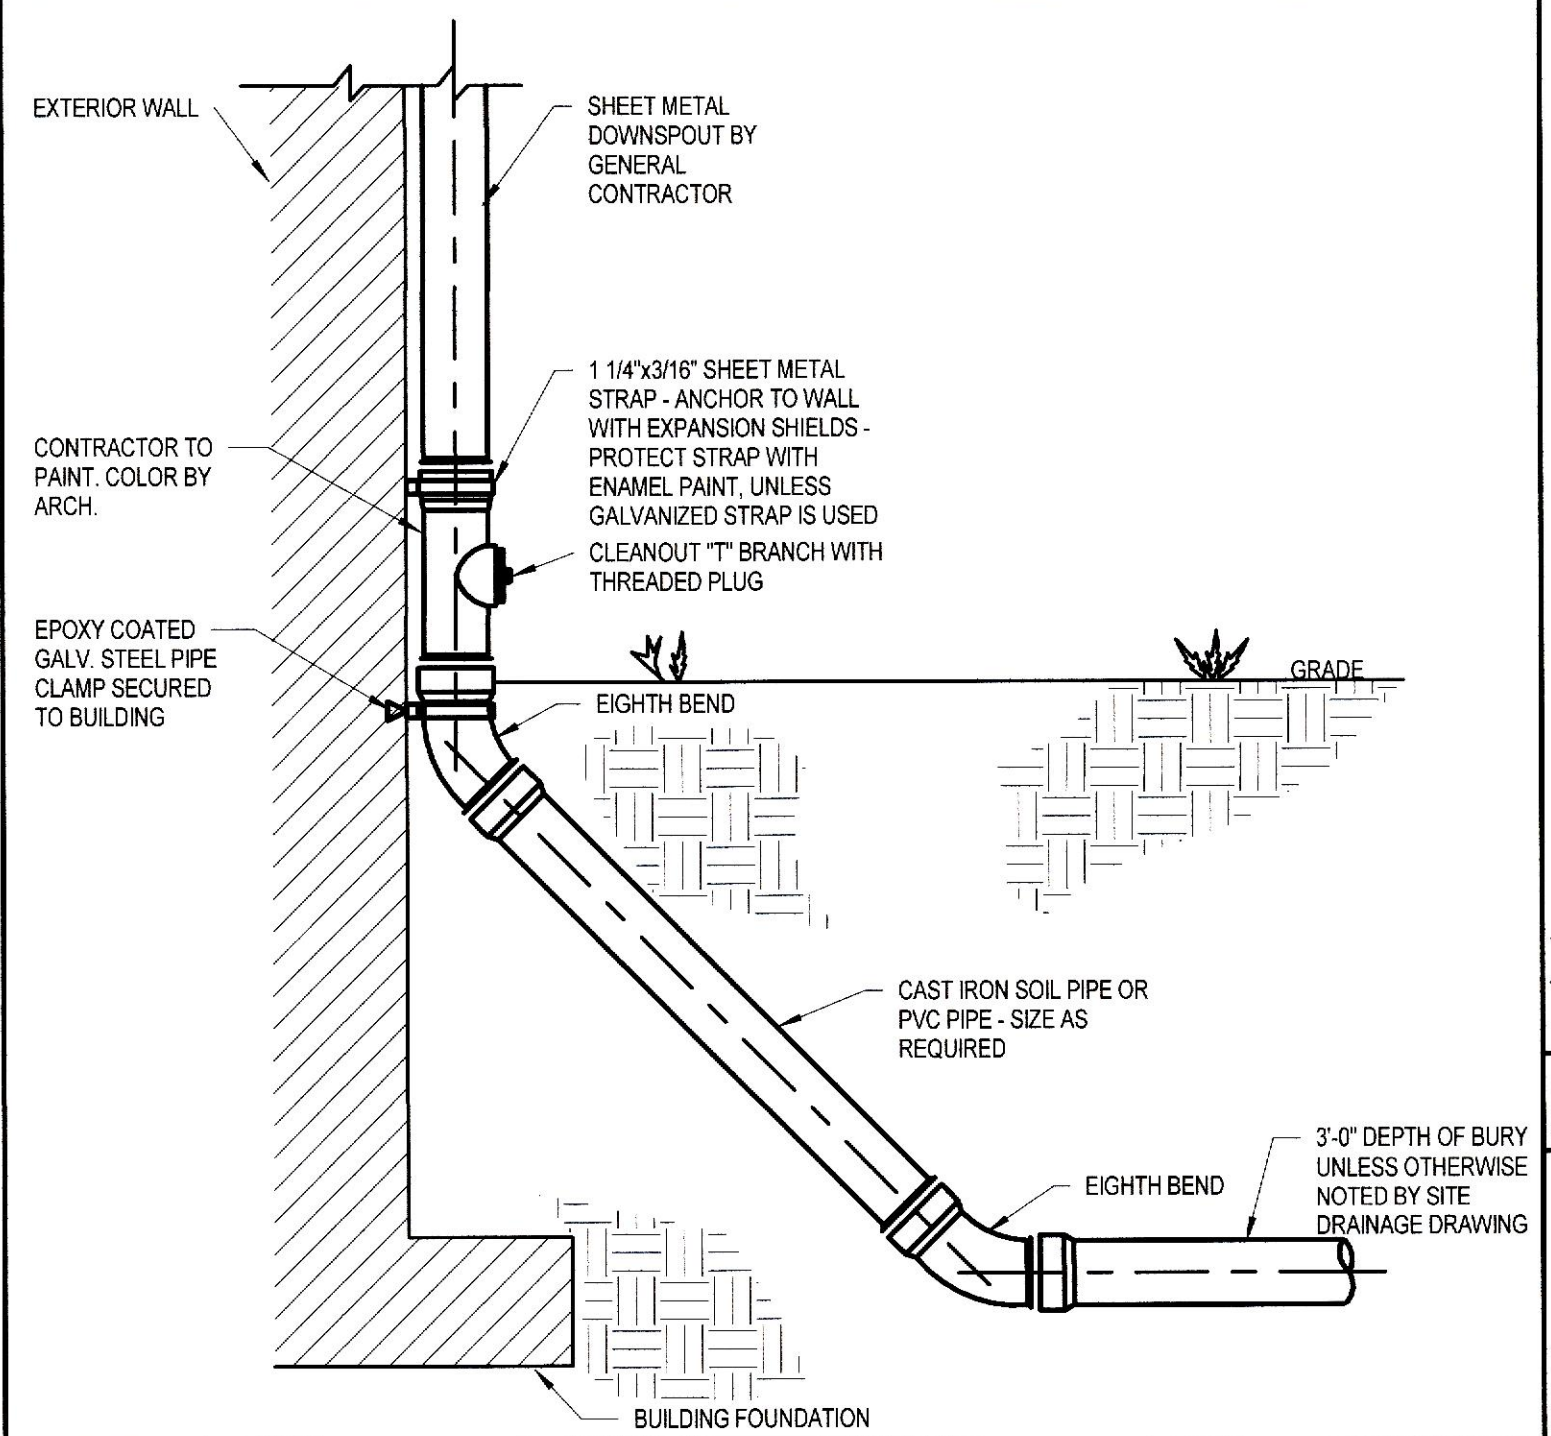


DOWNSPOUT DETAIL

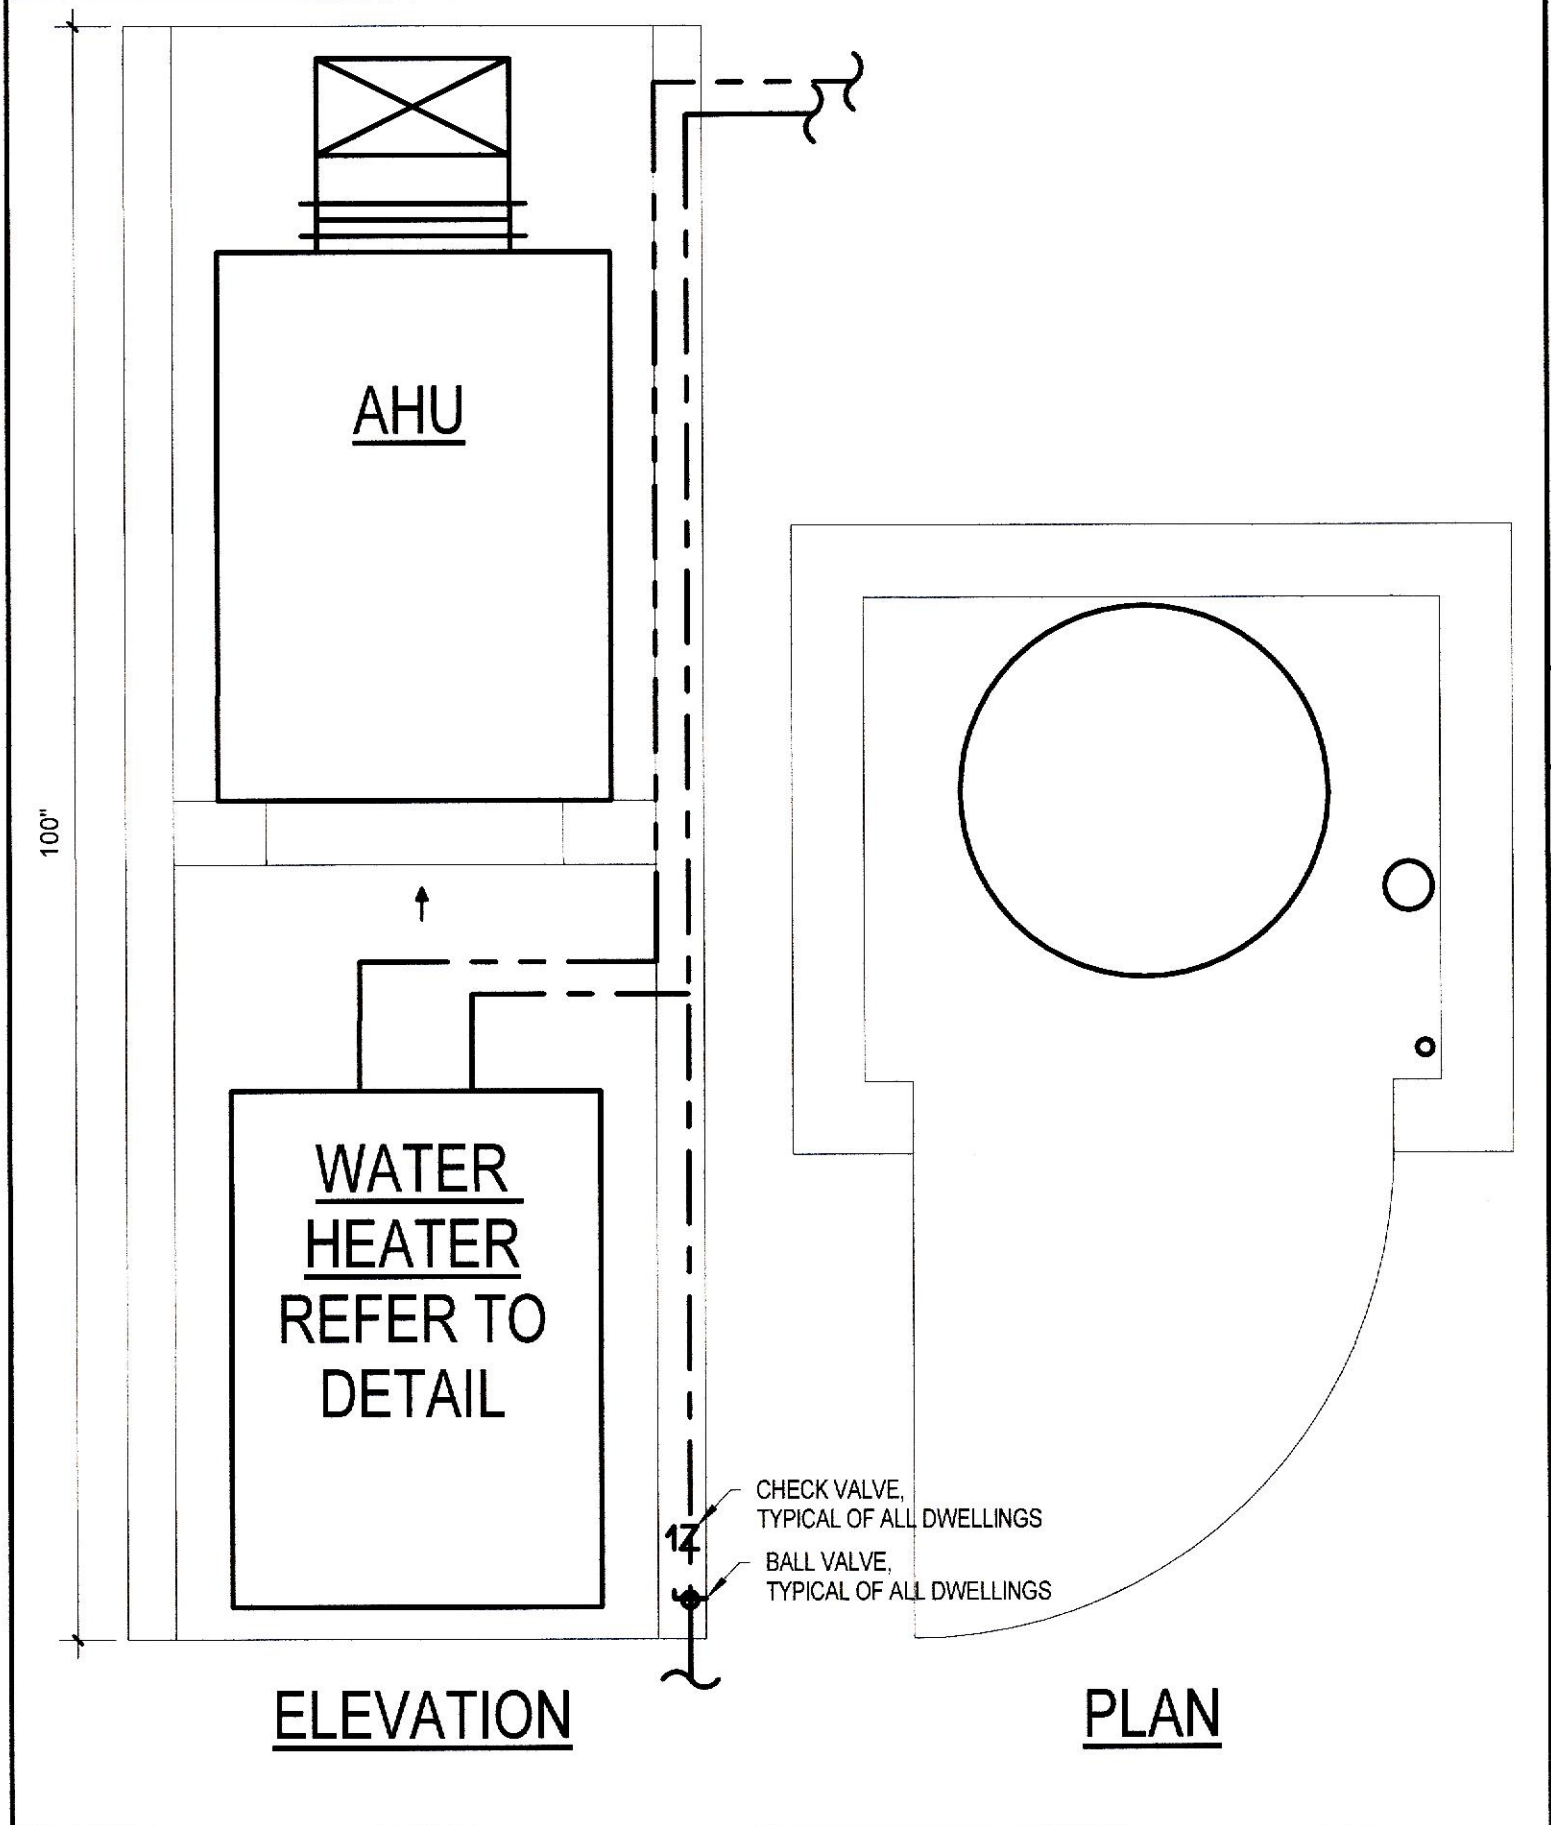


STACKED MECHANICAL CLOSET DETAIL - PLUMBING

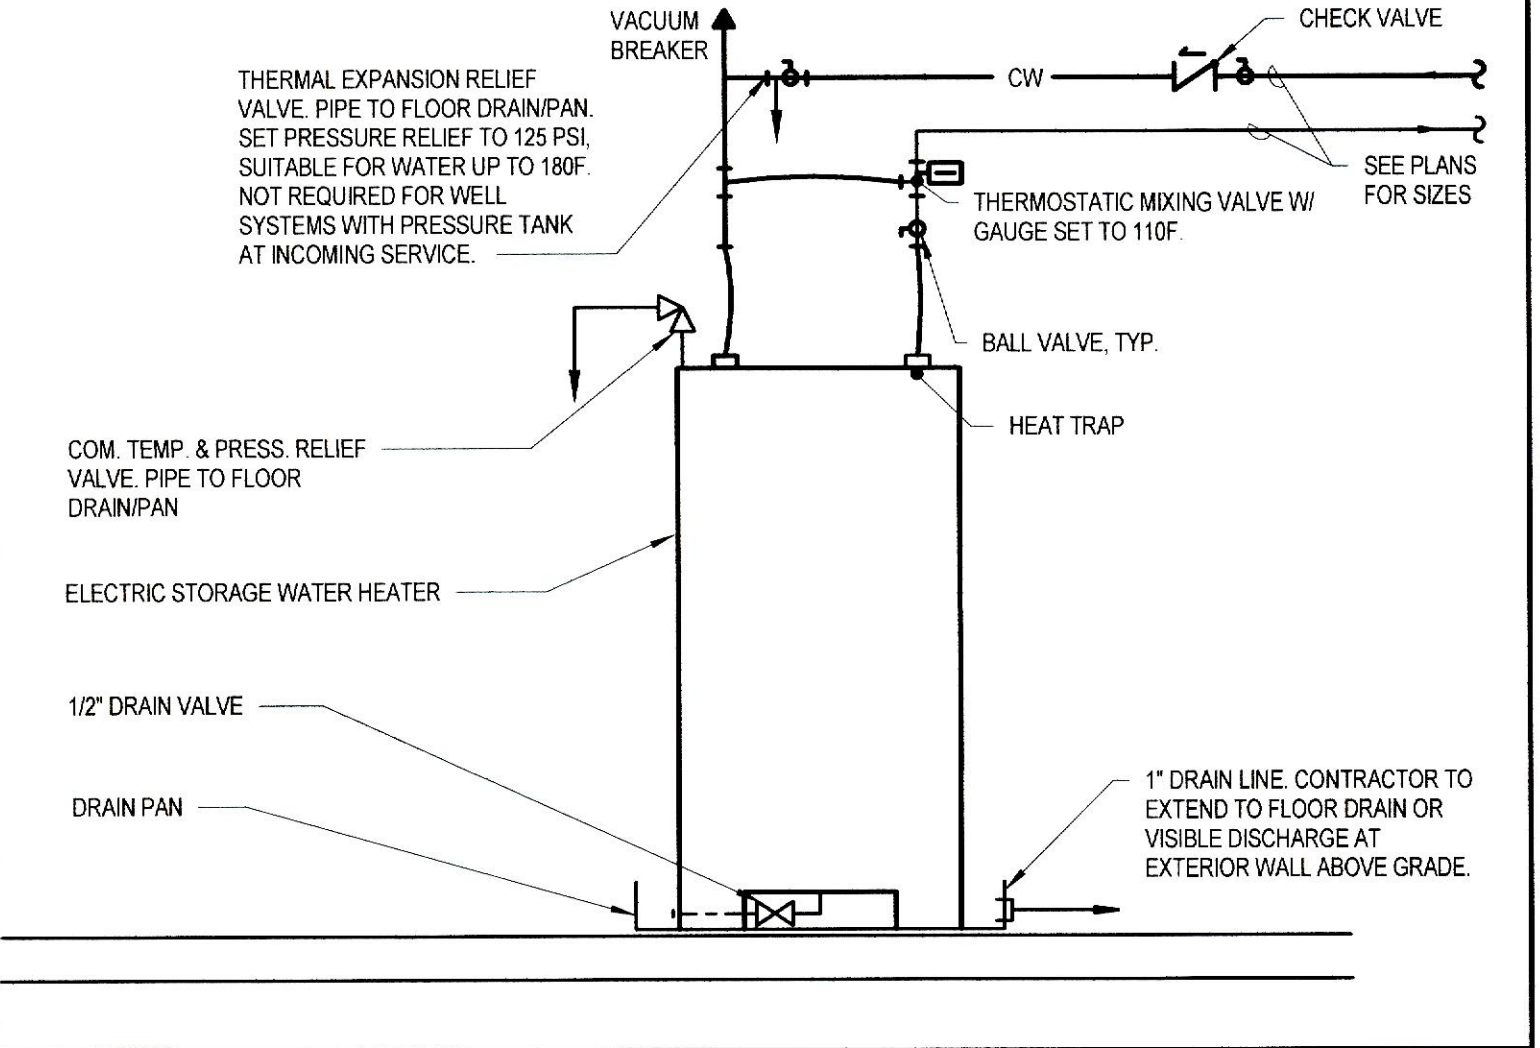

ELECTRIC STORAGE WATER HEATER DETAIL

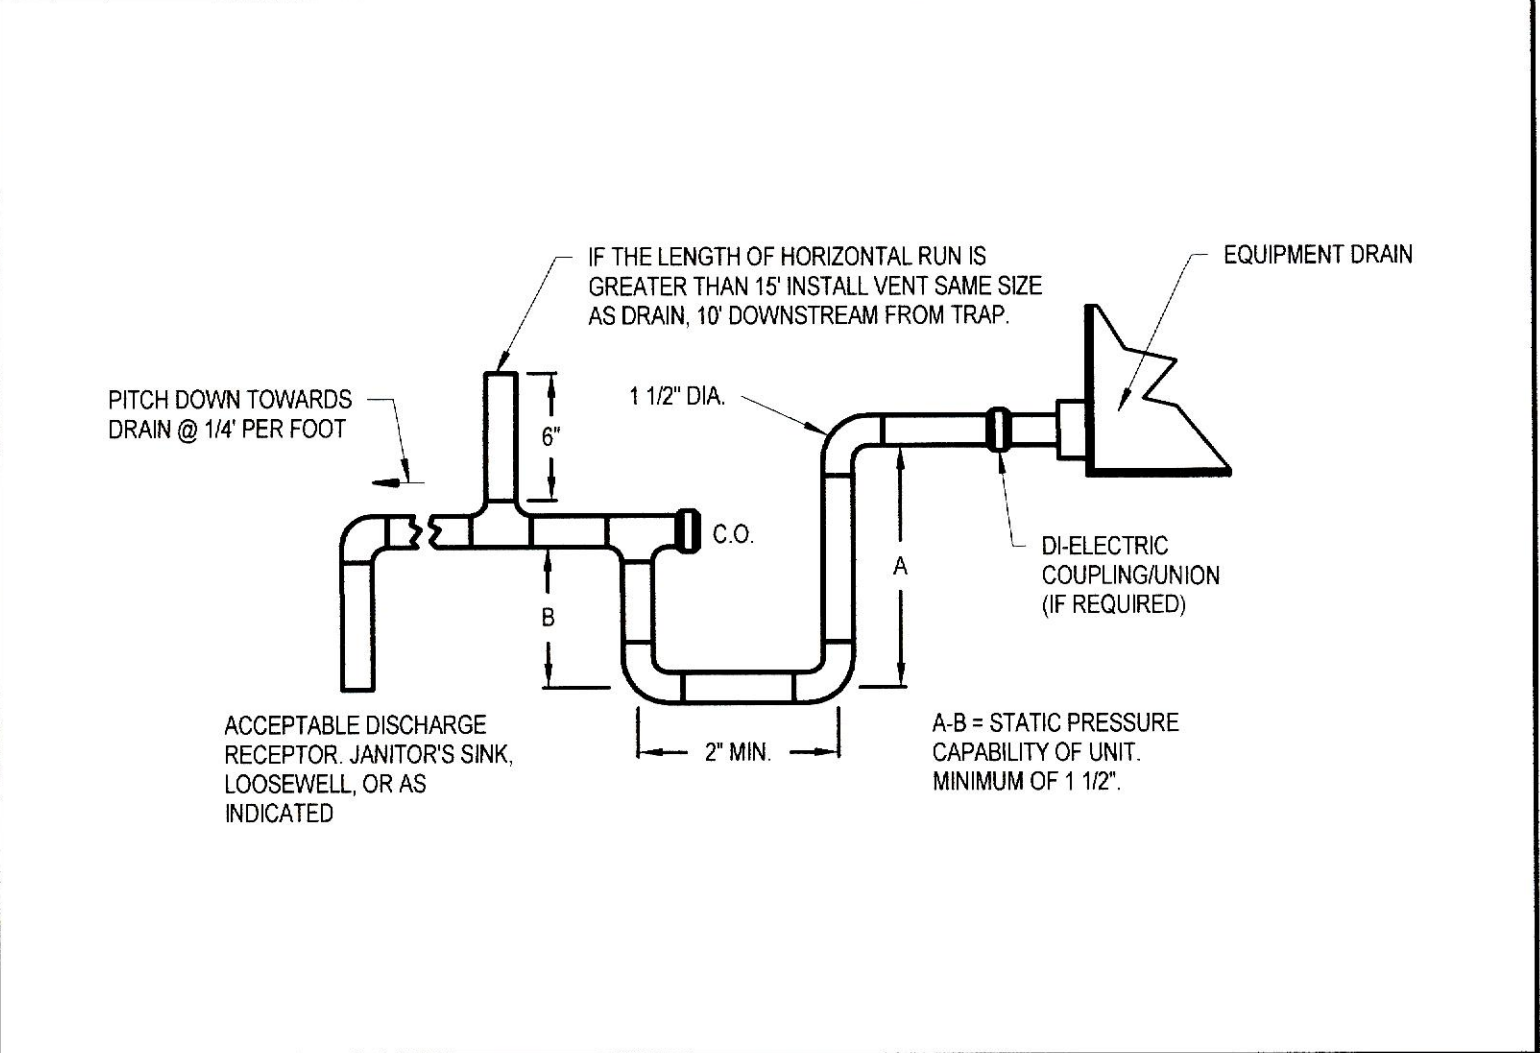

CONDENSATE TRAP

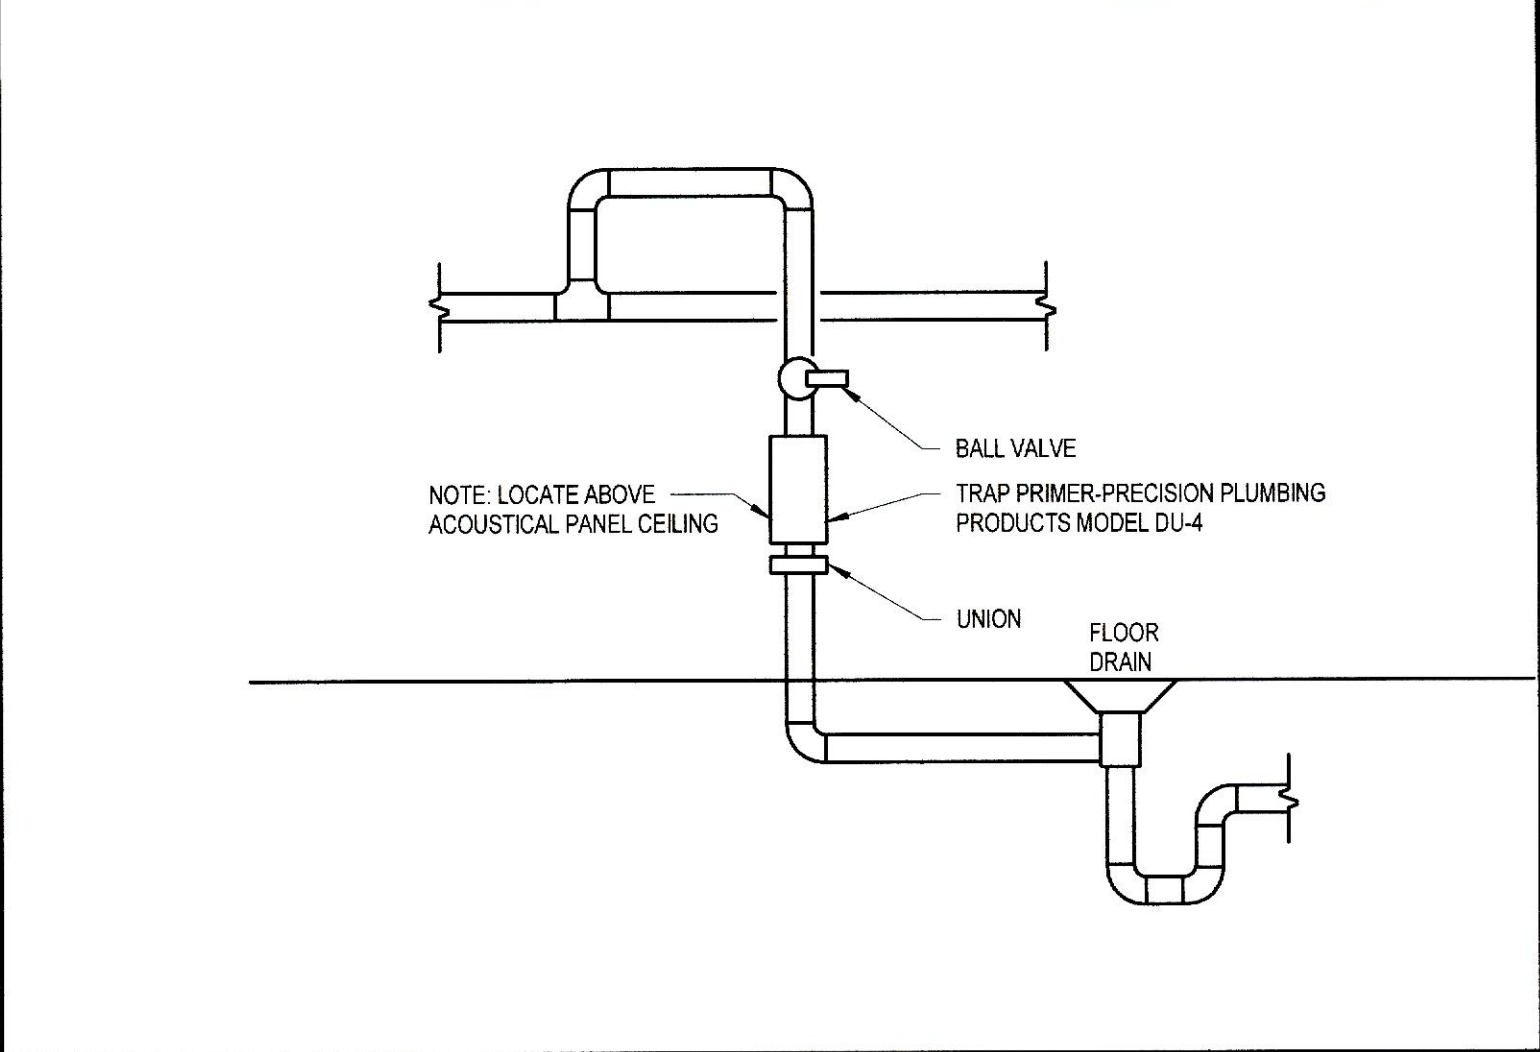

TRAP PRIMER DETAIL (TP-1)

PROJECT PROJECT NO. 22-15

Millington Senior Village

Residential Buildings

172 Sassafras Street
Millington, MD 21651

PRESENT **PRESENT COMPANY**

PROJECT DIRECTORY

DEVELOPER
Home Partnership of Cecil County, Inc
626 TOWNE CENTER DRIVE, SUITE 102
JOPPA, MD 21085
TEL 410.679.3200

CIVIL ENGINEER
Atwell, LLC
4692 MILLENNIUM DRIVE, SUITE 305
BELCAMP, MD 21017
TEL 302.369.2900

ARCHITECT
Present Company
2209 MARYLAND AVE
BALTIMORE, MD 21218
TEL 410.696.3321

STRUCTURAL ENGINEER
Skarda and Associates
2439 N CHARLES STREET
BALTIMORE, MD 21218
TEL 410.366.9384

MEP ENGINEER
Bowley Jones
1107 BURKHARDT LANE
SEVERN, MARYLAND, 21144
TEL 410.777.9493

ENERGY CONSULTANT
Lorax Partnerships, LLC
808 ST. PAUL STREET
BALTIMORE, MD 21202
TEL 443.449.6319

GENERAL CONTRACTOR
Willow Construction
8649 COMMERCE DRIVE
EASTON, MD 21601
TEL 410.622.6000

© 2024 PRESENT COMPANY. ALL RIGHTS RESERVED.

PROFESSIONAL CERTIFICATION

Professional Certification: I hereby certify that these documents were prepared or approved by me, and that I am a duly licensed professional engineer under the laws of the State of Maryland, License No. 51059, Expiration Date: 06-01-2027.

REVISIONS

1/28/25	4	MEP REVISIONS
DATE	NO.	ISSU

SUBMISSION

100% Construction Documents
PERMIT SET REISSUE
June 22, 2026

DRAWING NAME / NO. SCALE: As indicated

PLUMBING DETAILS

M503

9/25/2026 11:09:33 AM