

E  
D  
C  
B  
A

1

2

3

4

5


6

GENERAL NOTES:

- COORDINATE EXACT LOCATION OF DEVICES WITH ARCHITECTURAL ELEVATIONS. GENERALLY WHERE AN ARCHITECTURAL ELEVATION IS AVAILABLE, DEVICE MOUNTING HEIGHTS ARE OMITTED FROM THIS DRAWING.
- ALL TRADES ARE TO BE INDEPENDENTLY SUPPORTED. PER ALL TRADE STANDARDS AND NFPA. NOTHING CAN TOUCH THE SPRINKLER PIPING OR SUPPORT HANGERS. SYSTEMS CANNOT BE SUPPORTED FROM OTHER PARTS OF A SYSTEM. EACH PIPE SHOULD BE SUPPORTED INDEPENDENTLY OF EACH OTHER.
- REFER TO ARCHITECTURAL REFLECTED CEILING PLAN FOR EXACT LOCATION OF LIGHTING FIXTURES.
- ALL DEVICES INSTALLED ABOVE THE CEILING SHALL BE PROVIDED WITH LABELS INDICATING THE DEVICE OR EQUIPMENT INSTALLED ABOVE. ALL DEVICES INSTALLED ABOVE A "HARD" CEILING SHALL BE PROVIDED WITH AN ACCESS PANEL OF SUFFICIENT SIZE FOR DEVICE MAINTENANCE AND EVENTUAL REMOVAL.
- ALL CONDUIT INSTALLED ON THE EXTERIOR OF THE BUILDING SHALL BE RIGID GALVANIZED STEEL CONDUIT.
- ALL DISCONNECT SWITCHES INSTALLED ON THE EXTERIOR SHALL BE NEMA 4X ENCLOSURES.
- ALL CORRIDORS SHALL BE CONNECTED TO A SINGLE LIGHTING CONTROL MOOULE SERVING THIS AREA AND LEVEL. PROVIDE WITH KEY OPERATED OVERRIDE SWITCHES FOR EACH CORRIDOR.
- ALL FIRE ALARM DEVICES INDICATED ON THE EXTERIOR OF THE BUILDING SHALL BE WEATHERPROOF. ALL PENETRATIONS SHALL BE SEALED WEATHERTIGHT.
- ALL RECEPTACLES INSTALLED ON THE BUILDING EXTERIOR SHALL BE GFCI TYPE IN WEATHERPROOF LOCK-IN USE ENCLOSURES.
- ALL RECEPTACLES INSTALLED IN THE FACILITY SHALL BE TAMPER RESISTANT TYPE.


Keynotes

| NO.  | DESCRIPTION                      |
|------|----------------------------------|
| 7.06 | RECEPTACLE FOR FUTURE DRYER FAN. |

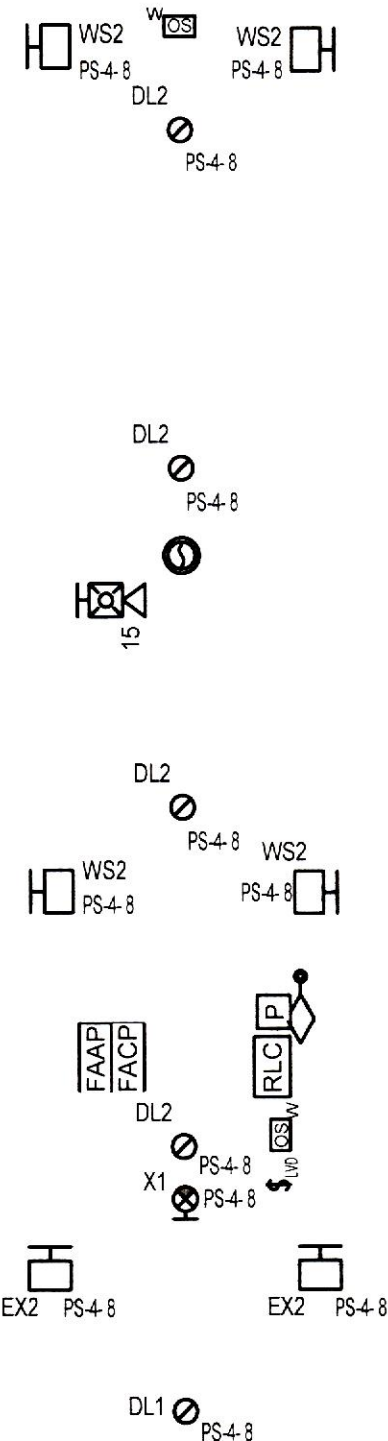

1 Typ Corridor - Lighting

E404 1/4" = 1'-0"

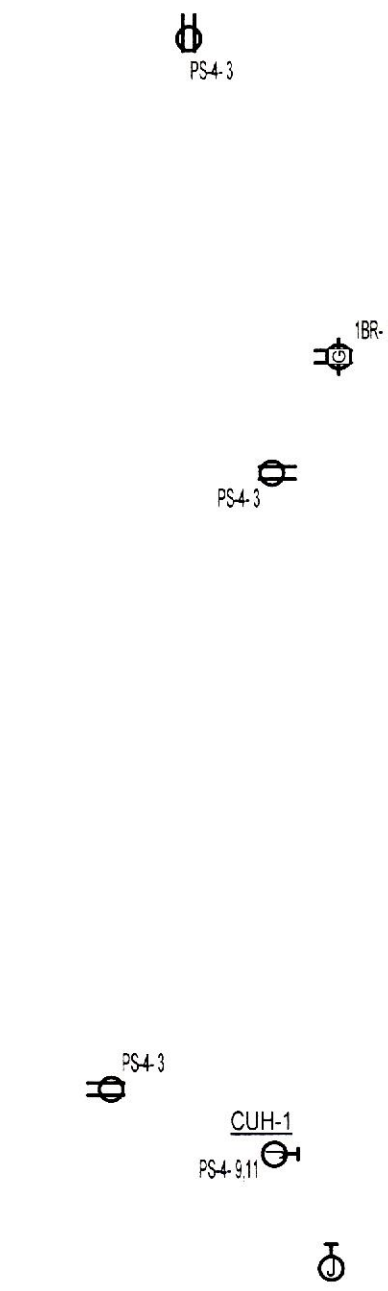


3 Typ Corridor - Power

E404 1/4" = 1'-0"



2 FLOOR PLAN - LEASING CENTER - LIGHTING AND FIRE ALARM

E404 1/4" = 1'-0"

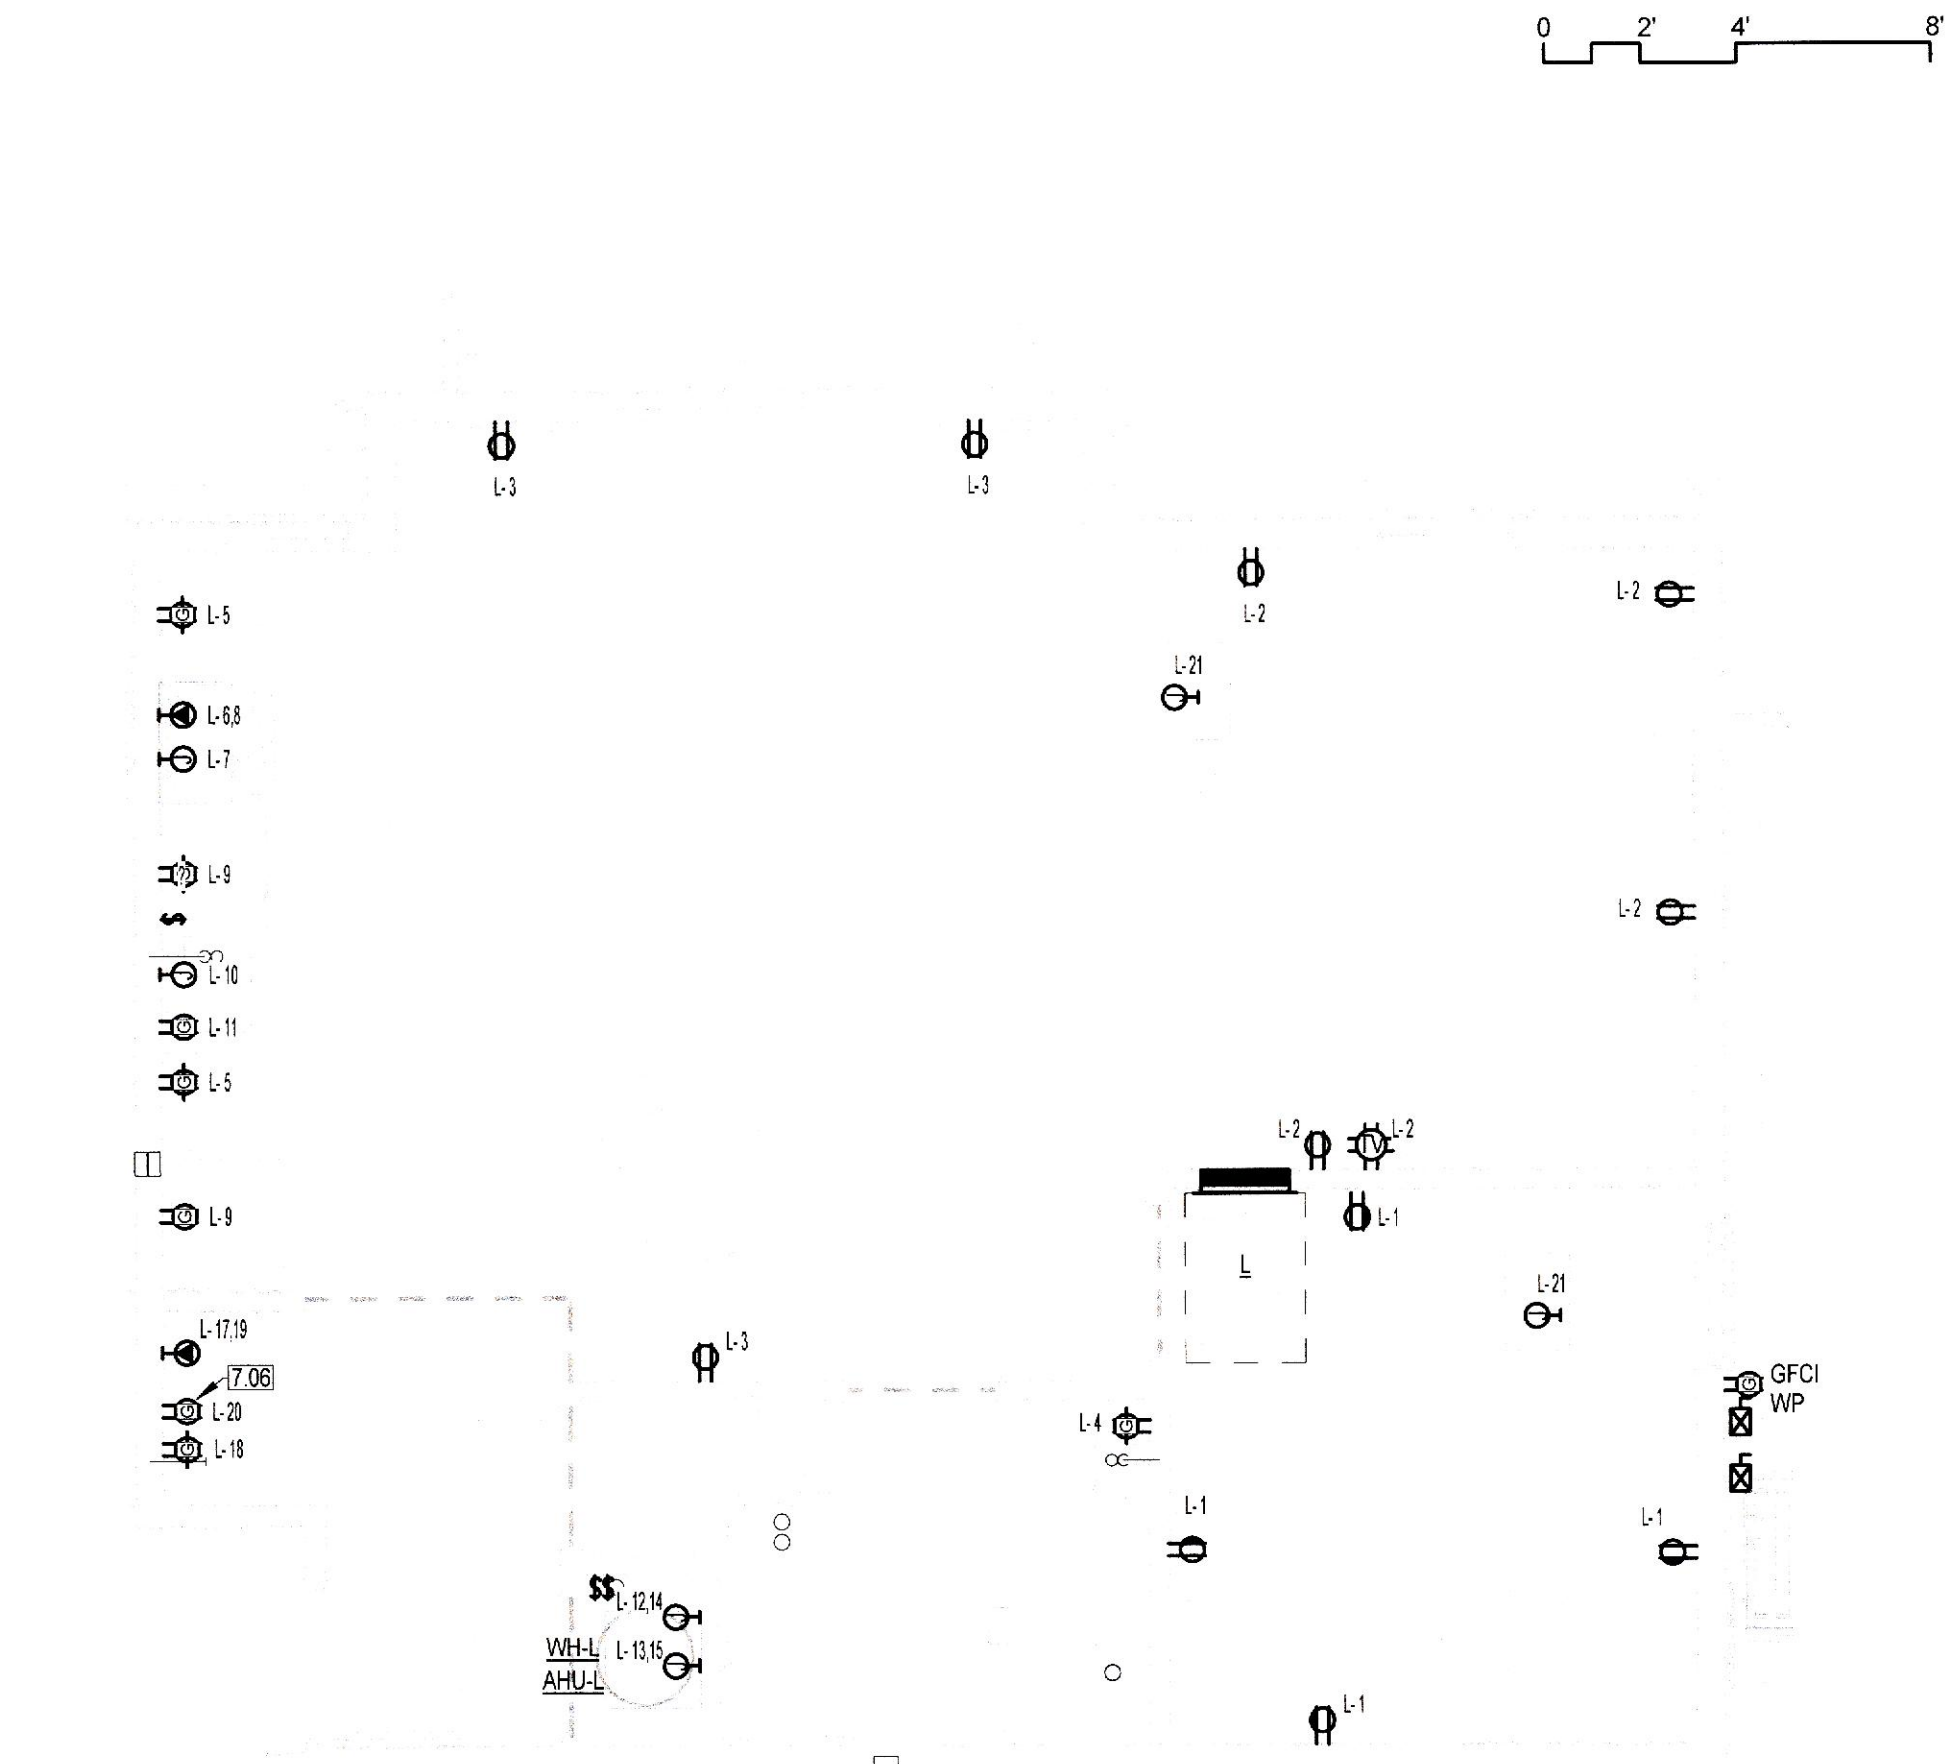

4 FLOOR PLAN - LEASING CENTER - POWER

E404 1/4" = 1'-0"

PROJECT PROJ. NO. 23-15

Millington Senior Village

Residential Buildings

172 Sassafra Street  
Millington, MD 21651

PRESENT PRESENT COMPANY

PROJECT DIRECTORY

DEVELOPER

Home Partnership  
of Cecil County, Inc.

626 TOWNE CENTER DRIVE, SUITE 102  
JOPPA, MD 21085

TEL 410.679.3200

CIVIL ENGINEER

Atwell, LLC

4692 MILLENNIUM DRIVE, SUITE 305  
BELCAMP, MD, 21017

TEL 302.369.2900

ARCHITECT

Present Company

2209 MARYLAND AVE  
BALTIMORE, MD 21218

TEL 410.696.3321

STRUCTURAL ENGINEER

Skarda and Associates

2439 N CHARLES STREET  
BALTIMORE, MD 21218

TEL 410.366.9384

MEP ENGINEER

Bowley Jones

1107 BURKHARDT LANE  
SEVERN, MARYLAND, 21144

TEL 410.777.9493

ENERGY CONSULTANT

Lorax Partnerships, LLC

808 ST. PAUL STREET  
BALTIMORE, MD 21202

TEL 443.449.6319

GENERAL CONTRACTOR

Willow Construction

8649 COMMERCE DRIVE  
EASTON, MD 21601

TEL 410.822.6000

© 2024 PRESENT COMPANY. ALL RIGHTS RESERVED.

PROFESSIONAL CERTIFICATION



Professional Certification. I hereby certify that these documents were prepared or approved by me, and that I am a duly licensed professional engineer under the laws of the State of Maryland. License No. 51059. Expiration Date: 06-01-2027.

REVISIONS

6/22/2026 8 Permit Set Revisions

DATE NO. ISSU

SUBMISSION

100% Construction Documents  
PERMIT SET REISSUE  
June 22, 2026

DRAWING NAME / NO. SCALE: 1/4" = 1'-0"

ENLARGED VIEWS - ELECTRICAL

E404

6/25/2026 11:00:11 AM